

PLANT SCHEDULE

TREES					
QNTY	ABBRV	SCIENTIFIC NAME	COMMON NAME	PLANTING SIZE	MISCELLANEOUS / REMARKS
2	LIM	Lagerstroemia indica 'Pink Velour'	Pink Velour Crape Myrtle	B & B OR CONT. ; 10' - 12' O.A. HT.	Specimen, Multistem
1	MGCW	Magnolia grandiflora 'Claudia Wanamaker'	Claudia Wanamaker Southern Magnolia	B & B OR CONT. ; 14 - 16 O.A. HT	Specimen, Full to Ground

PALMS					
QNTY	ABBRV	SCIENTIFIC NAME	COMMON NAME	PLANTING SIZE	MISCELLANEOUS / REMARKS
8	SR	Sereno repens	Saw Palmetto	CONT. ; 24" O.A. HT.	Full ToThe Ground
1	TF	Trachycarpus fortunei	Windmill Palm	B & B ; 6' HT. X 3' SPD.	Multi-stem 2 stagger HT. trunks


SHRUBS					
QNTY	ABBRV	SCIENTIFIC NAME	COMMON NAME	PLANTING SIZE	MISCELLANEOUS / REMARKS
12	CGD-P	Distylium 'Cinnamon Girl' PP #027631	Cinnamon Girl Distylium	CONT. 18" X 18"	Full
58	PDPD	Podocarpus macrophyllus 'Pringles Dwarf'	Pringles Dwarf Podocarpus	CONT. ; 12" X 24"	Full to ground and well formed

ORNAMENTAL GRASSES AND GROUNDCOVERS					
QNTY	ABBRV	SCIENTIFIC NAME	COMMON NAME	PLANTING SIZE	MISCELLANEOUS / REMARKS
6	COEO	Carex oshimensis 'EverOro'	Evercolor Sedge	CONT. ;	Full and well formed
3	GSPA	Gelesium sempervirens 'Pride of Augusta'	Double Carolina Yellow Jessamine	CONT. ; 36" O.A. HT.	Full and well formed
185	TRAA	Trachelospermum asiaticum	Asiatic Jasmine	1 Gal. ; 6" O.A. HT.	Full and well formed
900	SOD	Zoysia japonica x Z. tenuifolia	Emerald Zoysia	Dense roots -----	Measure in Square Feet


Continued:
Optional 1: See Illustration #2
1. For light traffic applications:
Install perforated or slotted SDR35 Pipe to increase
vertical loading strength as shown.

Optional 2: See Illustration #1
2. For water back up prevention:
Vent downspout and use surface drain to allow overflow
of excess water away from Flow-Well.
3. To capture collected surface water:
Place the Flow-Well at the lowest elevation point and install surface
drain directly on top of cover.

Illustration #2



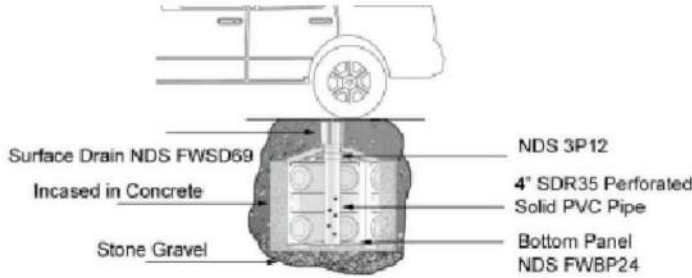


New Flow-Well Features:
*Added center 4" cover knock-out
*Added center 8" cover cut-out
*Added center "Universal Adapter" cover cut-out
*Added ramp "U" cover cut-out
*Added 4" SCH 40 and 4" SDR 35 panel knock-out ports
*Added "Universal Adapter" panel cut-out

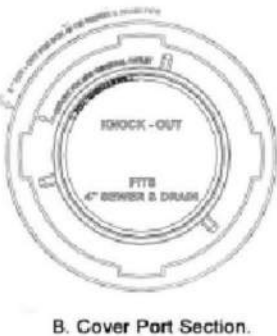

Installation Example: Groundwater Recharge Hardpipe.

Illustration.1

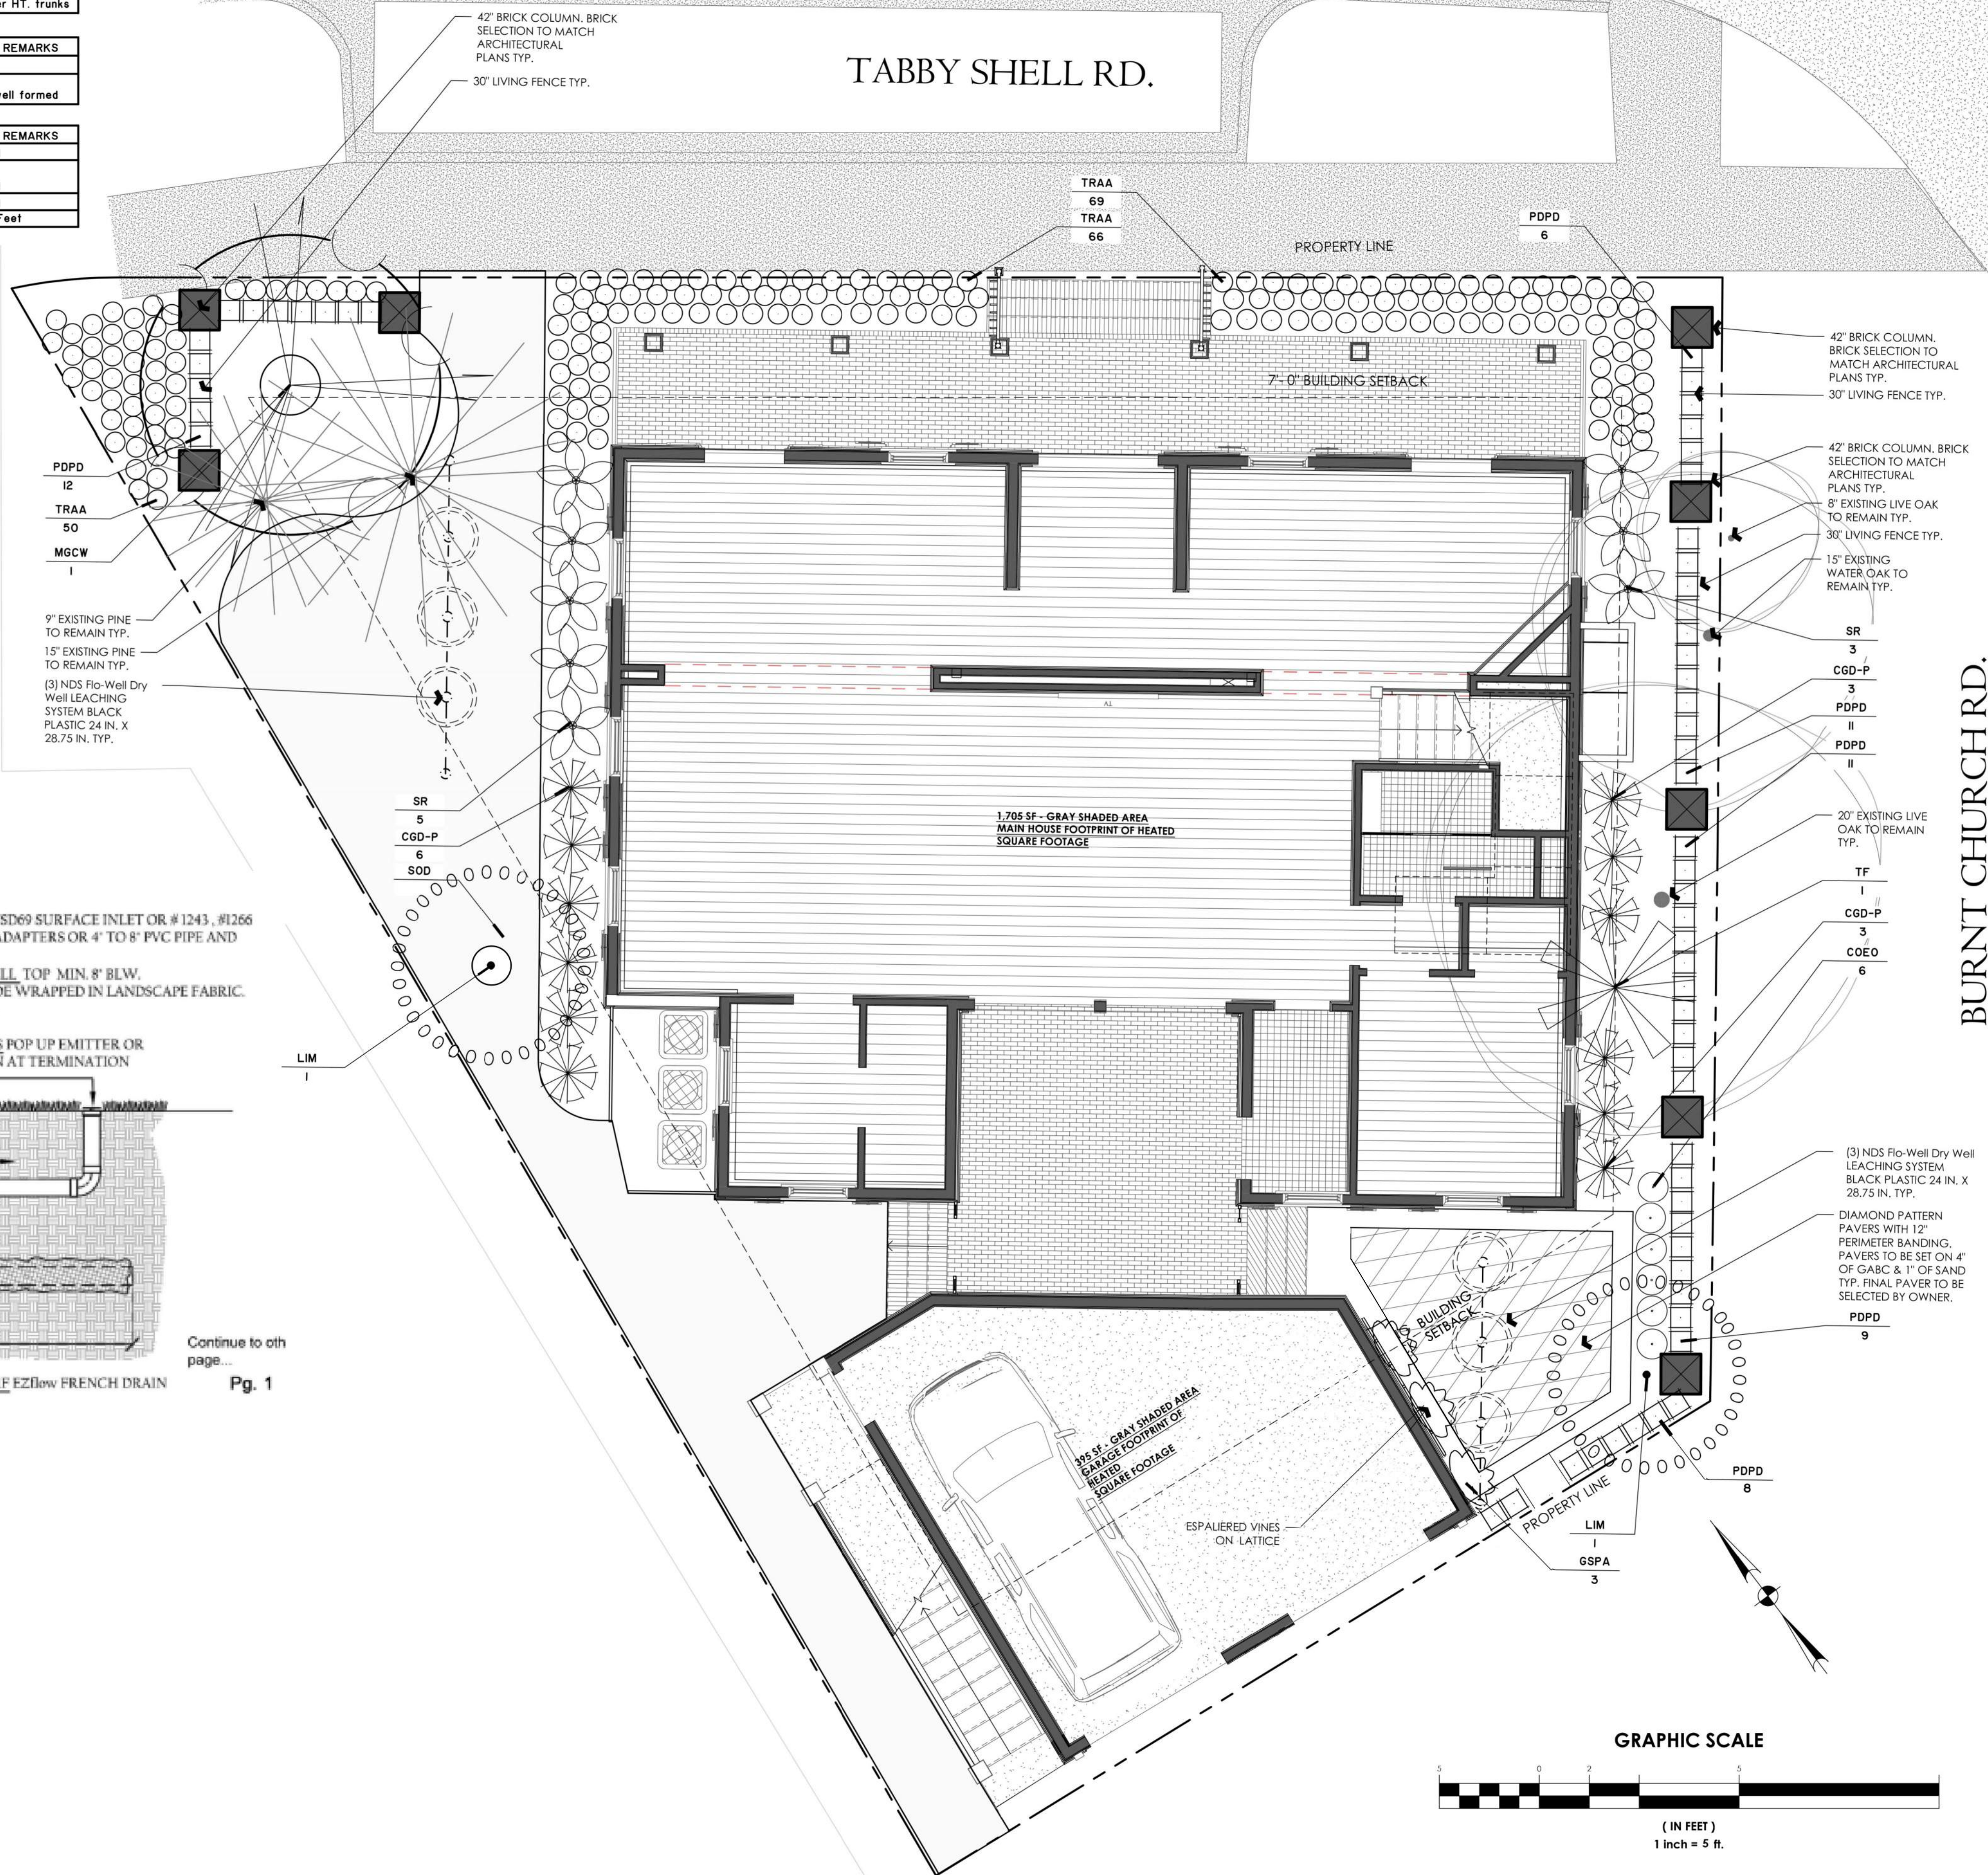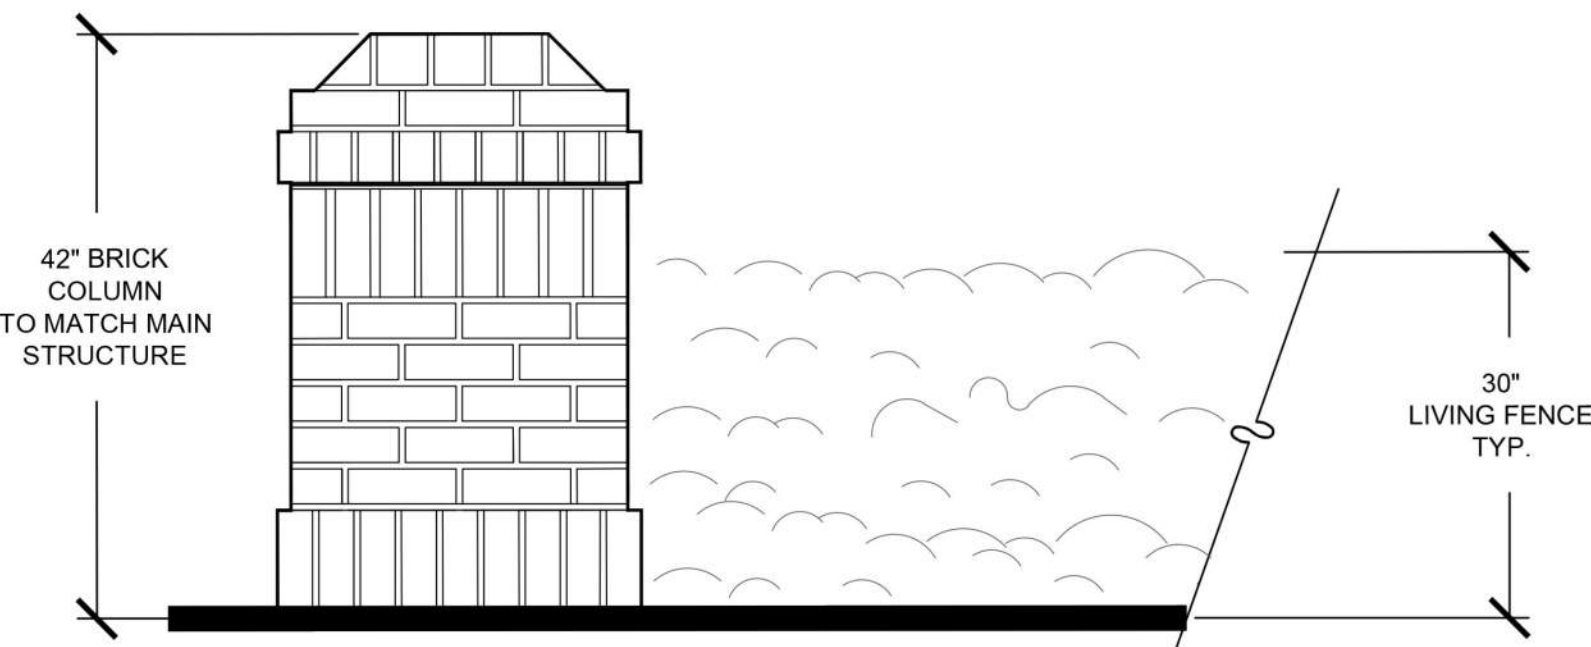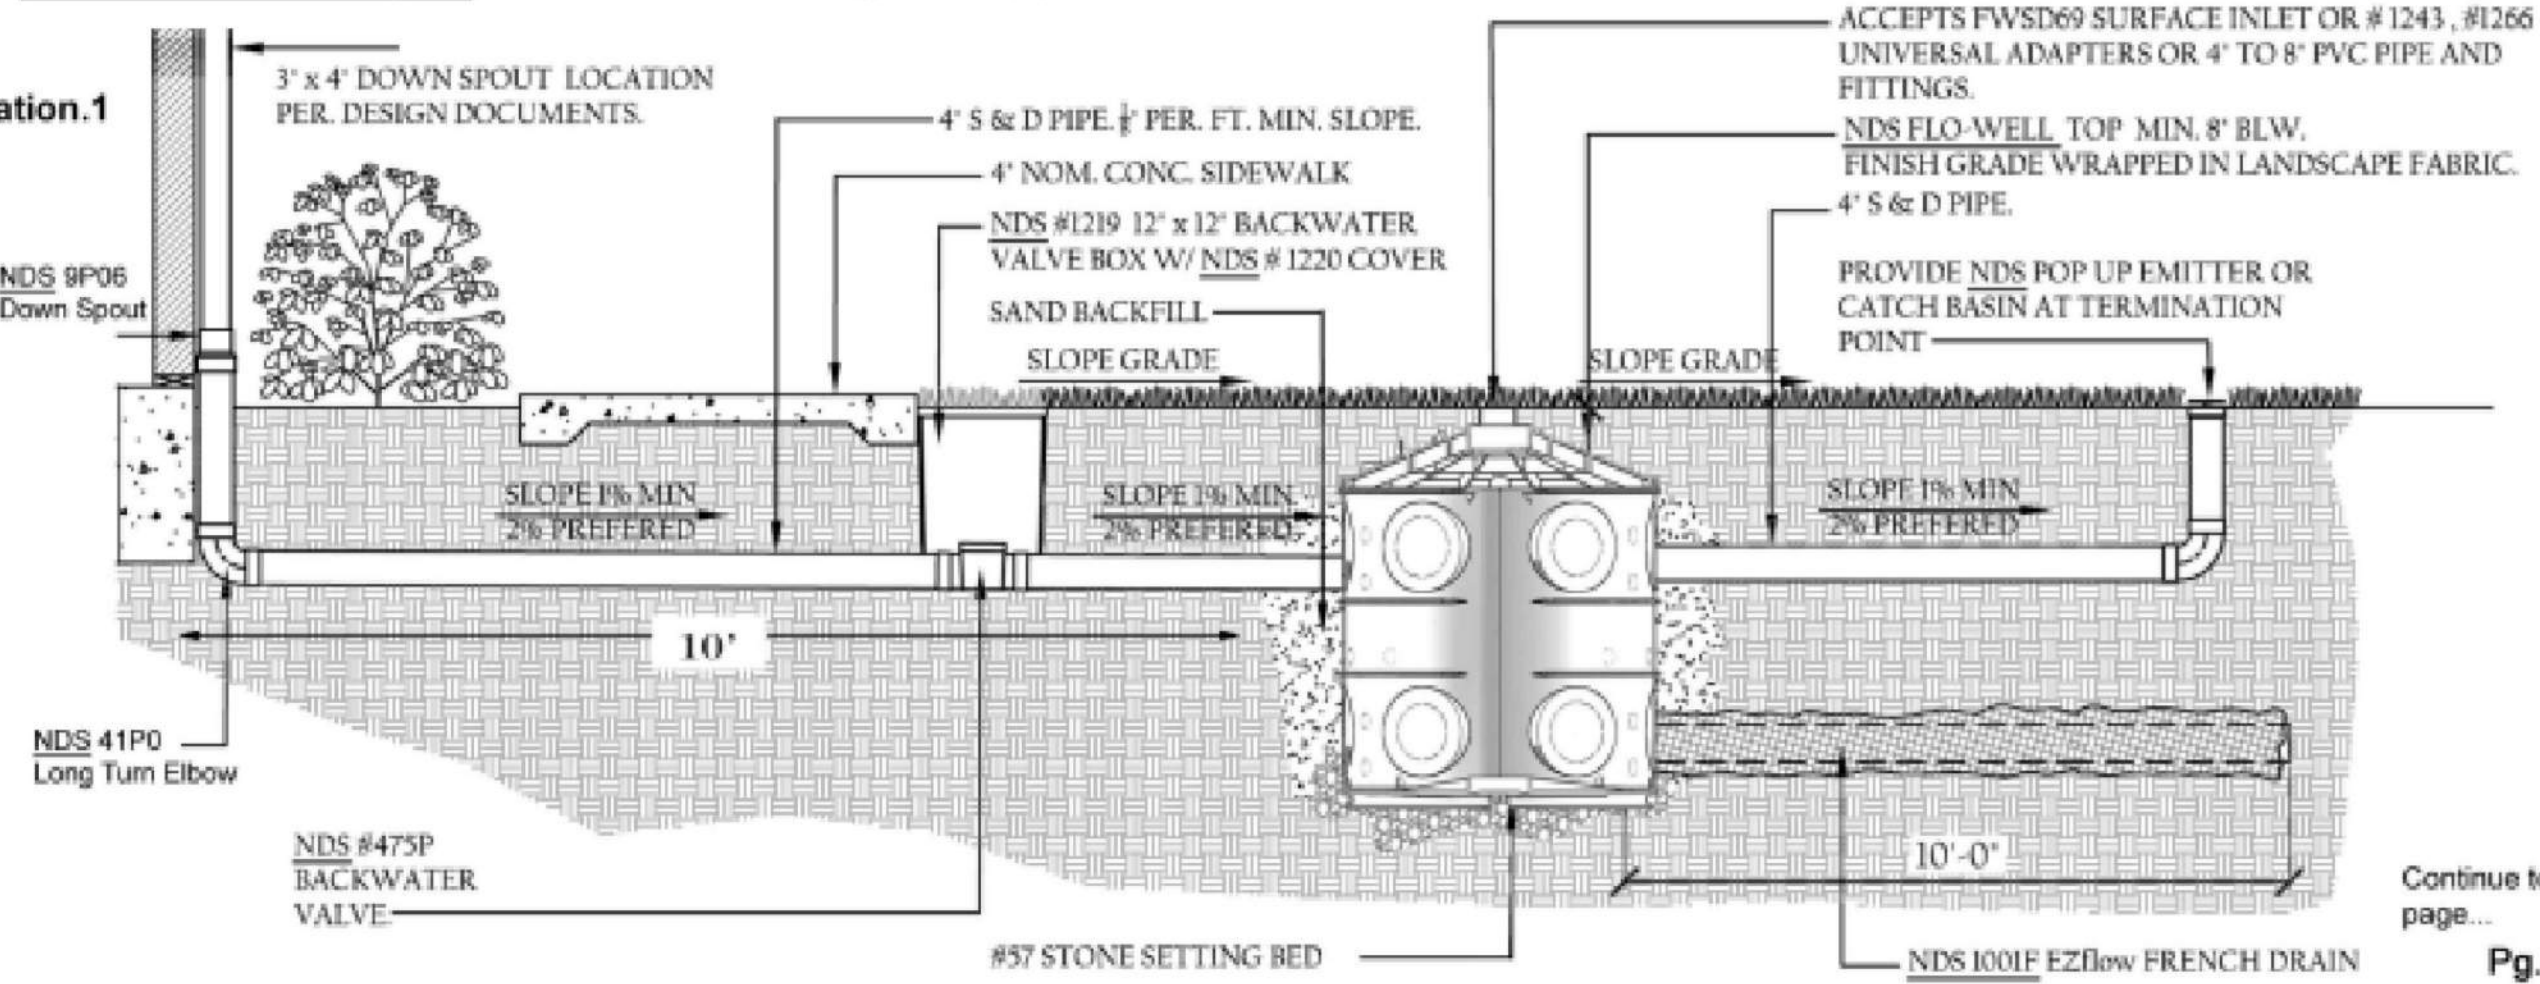

BURNT CHURCH RD.

THOMAS & HUTTON
50 Park of Commerce Way
Savannah, GA 31405 • 912.234.5300
www.thomasandhutton.com

GERING RESIDENCE
36 TABBY SHELL ROAD, BLUFFTON, SC
XXXXX
HARDSCAPE AND PLANTING PLAN

JOB NO: J-8DEV
DATE: 08/21/2023
DRAWN: JLG
DESIGNED: JLG
REVIEWED: JLG
APPROVED: JLG
SCALE:

L1.0