


NOTES:

- Customers are responsible for confirming mounting heights, fixture suspension types/ lengths, color temperature, CRI, linear fixture lengths, pole lengths, and bollard heights/ lengths prior to ordering.
- Mounting height (MH) is measured from the bottom of the fixture to the floor.
- This Lighting layout assumes the following unless values are specified and must be confirmed by the customer prior to ordering.
 - Room reflectance of 80, 50, 20 for standard ceilings and 50, 50, 20 for exposed ceilings
 - Wall sconces are mounted at 7' for calculation purposes. Customer must confirm desired mounting height before rough in.

Calculation Summary						
Label	CalcType	Units	Avg	Min	Max	MountHt
001	RoomArea	Ft ²	3.44	0.00	N/A	N/A
PARKING AND DRIVE	RoomArea	Ft ²	0.93	0.0	N/A	N/A

Landscape Schedule						
Qty	Label	Arrangement	LF	MPS	Description	Lot/Landsc
12	OA3	Single	0.900	UTICORNA	RS01 LED P1 var 40 140 FT POL: PT BASE	01.34 819.08 7098
19	OA4	Single	0.900	UTICORNA	RS01 LED P1 var 54 140 FT POL: PT BASE	01.34 919.45 7199
14	OA5	Single	0.900	UTICORNA	RS01 LED P1 var 45 140 FT POL: PT BASE	01.34 718.76 7094
4	OA5-2 HEAD	Single	0.900	UTICORNA	RS01 LED P1 var 45 140 FT POL: PT BASE	01.34 419.72 7094
4	OB1	Single	0.900	LUMENS	RS01 LED P1 var 45 140 FT POL: PT BASE	70.2 119.2 1092

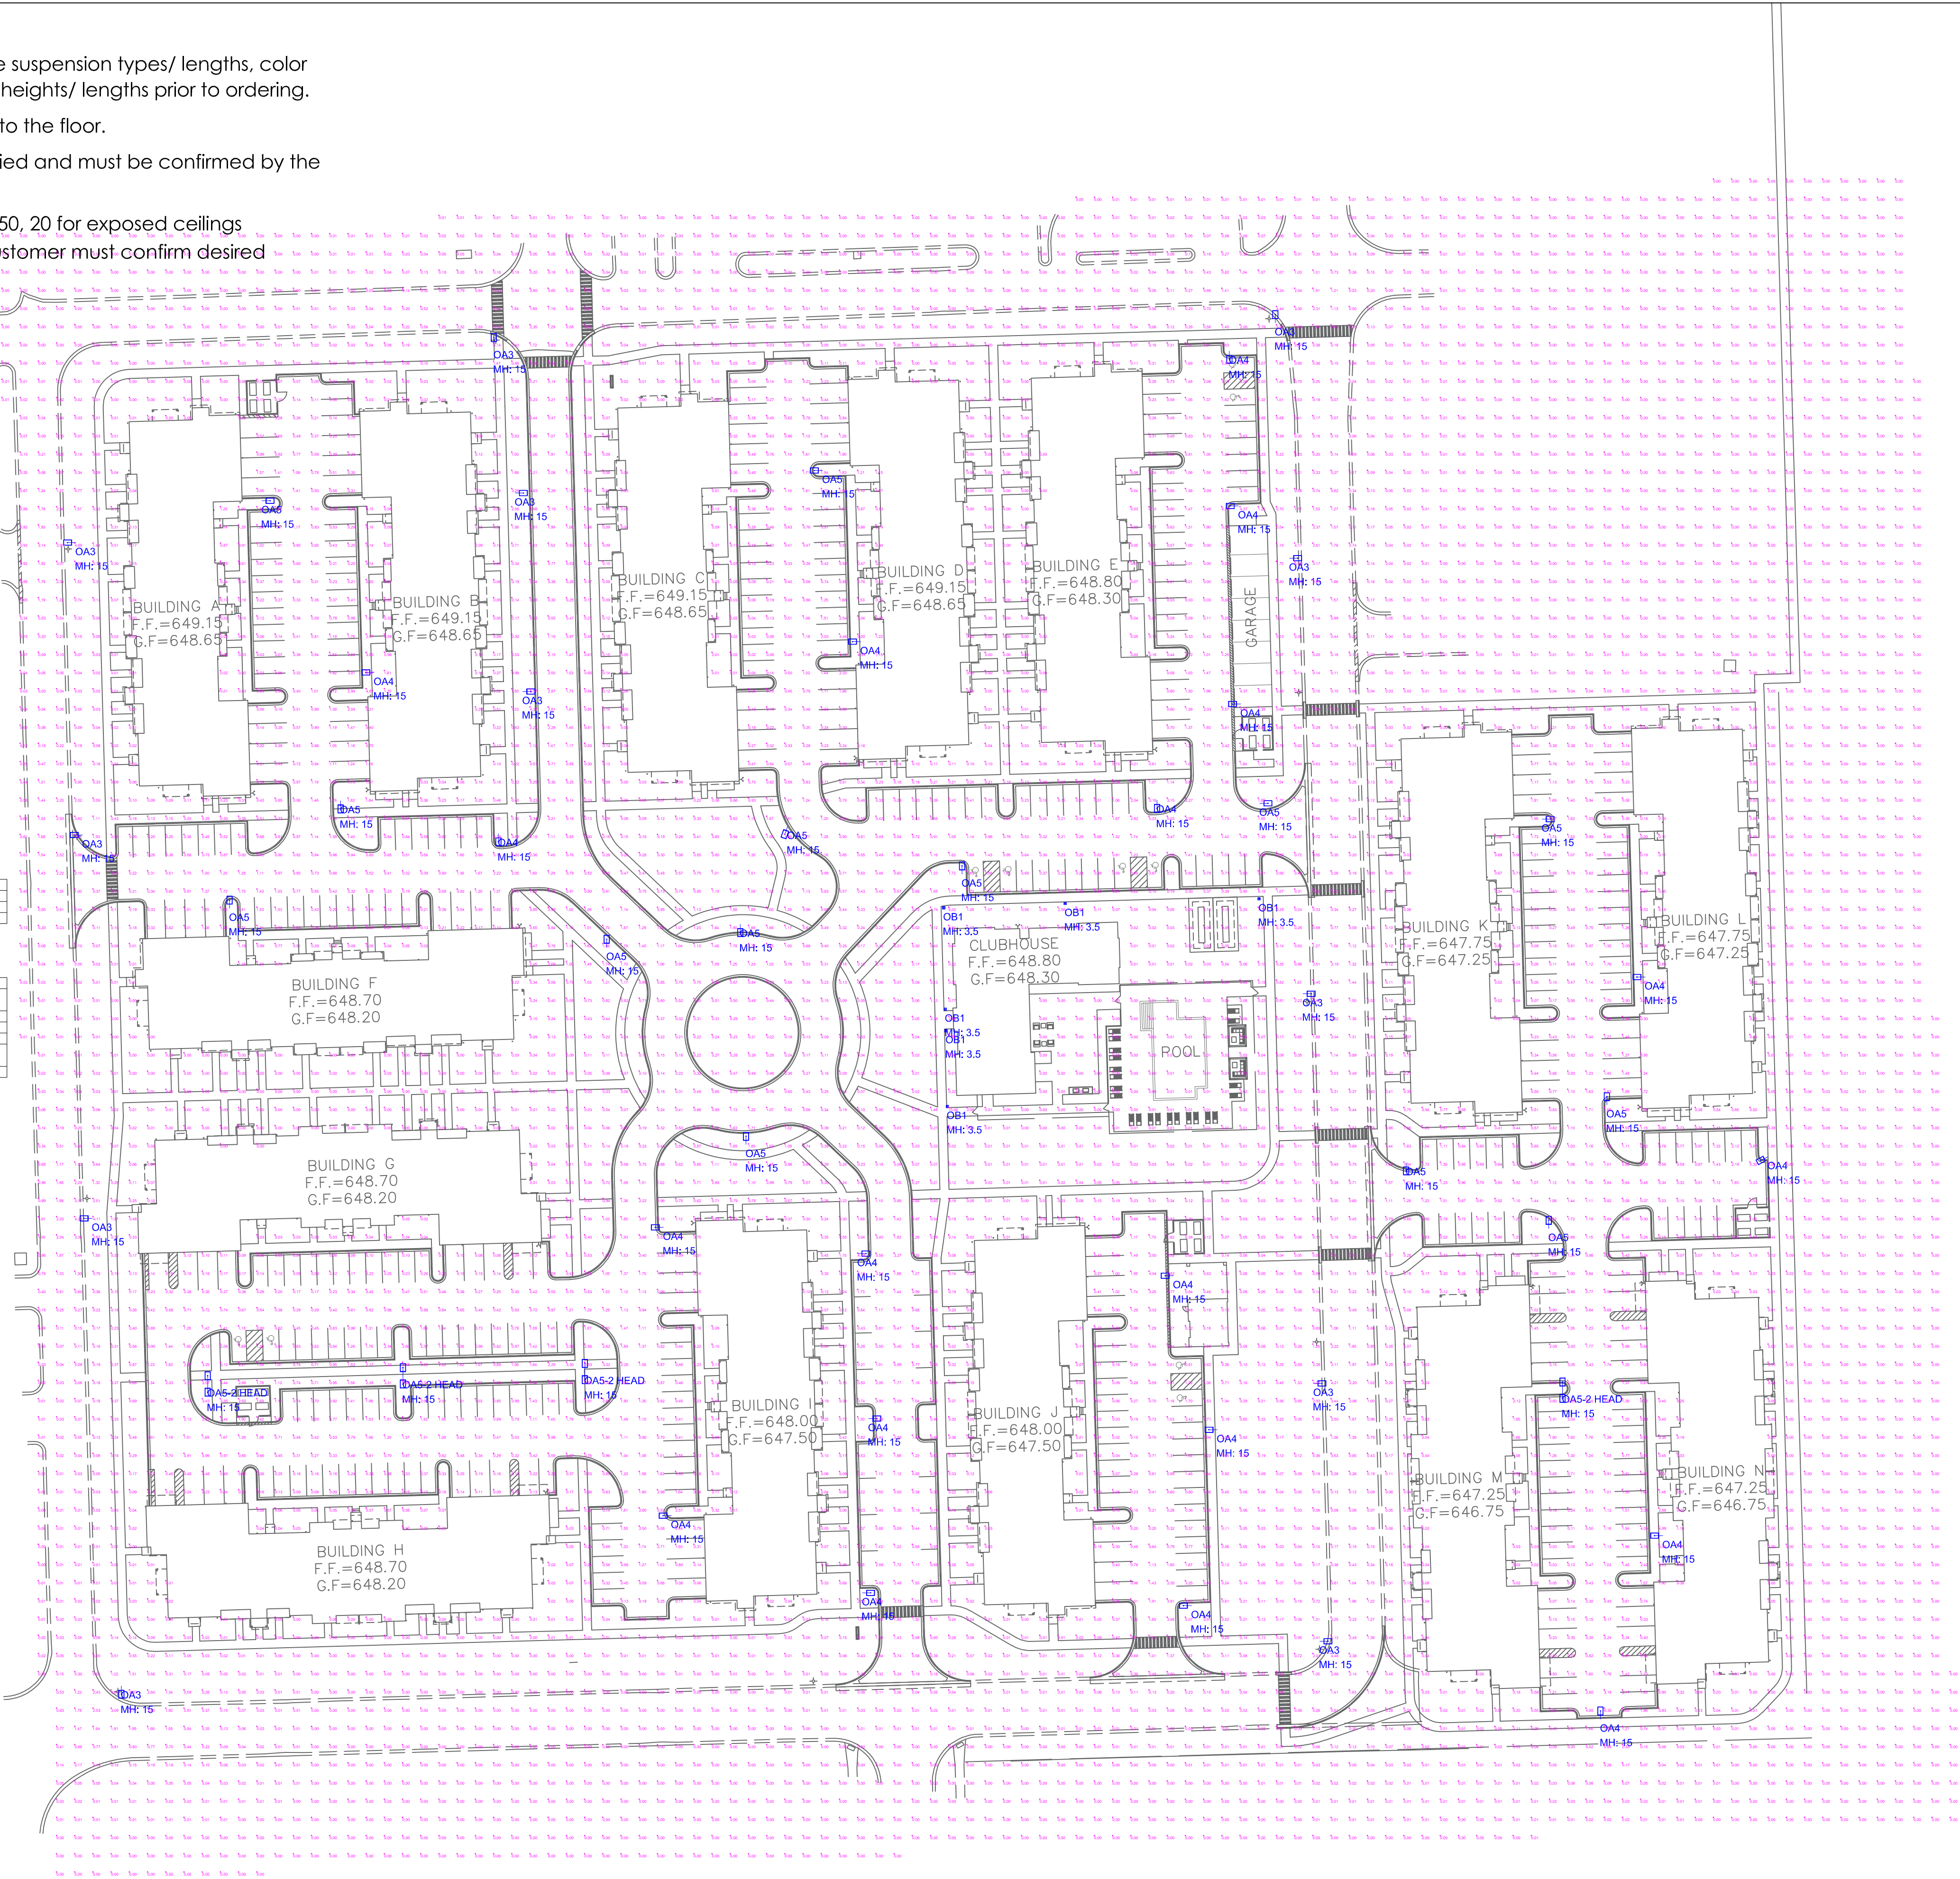

ENTERPRISE
Lighting & Control



COMMENTS

DATE

#

REVISIONS

DRAWN BY : BB

DATE : JAN 13, 2026

SCALE : 1" = 50'-0"

SEASONS AT CREST HILL

CREST HILL, IL

SITE LIGHTING LAYOUT