

CITY OF DYERSVILLE SANITARY SEWER EXTENSION

Project: OLDE CASTLE ROAD SANITARY SEWER EXTENSION 2025 LETTING DATE XXXXXX

OLDE CASTLE ROAD SANITARY SEWER EXTENSION 2025 DYERSVILLE, IOWA

UTILITY PROVIDER CONTACTS

ALLIANT ENERGY
TERRY DEMPWOLF
563-543-5885
terrydempwolf@alliantenergy.com

GAS (HEATING)
BLACK HILLS ENERGY
JAN KRUEGER
JAN.KRUEGER@BLACKHILLSCORP.COM
1-888-890-5554

COMMUNICATIONS
COMELEC INTERNET SERVICE
563-557-8442
AND
WINDSTREAM COMMUNICATIONS
LOCATE DESK
WWW.IOWATELECOM.NET
1-800-347-1991

LUMEN TECHNOLOGIES
877-453-8353

MAQUOKETA VALLEY ELECTRIC COOPERATIVE
800-927-6068
ELECTRIC 800-582-8998
FIBER 877-811-1568

IA DEPT. OF TRANSPORTATION
JOE KILBURG
563-582-3063
JOEKILBURG@IOWADOT.US

IA COMMUNICATIONS NETWORK
SHANNON MARLOW
515-725-4402
shannon.marlow@iowa.gov

MEDIACOM
WWW.MEDIACOMCC.COM
1-855-633-4226


DISH NETWORK
1-800-896-4616

GARBAGE, RECYCLING BINS
BI-COUNTY DISPOSAL
563-875-9076

WATER & WASTEWATER
DYERSVILLE UTILITIES
TERRY RECKER
563-875-7724
WWW.CITYOFDYERSVILL.COM



VICINITY MAP

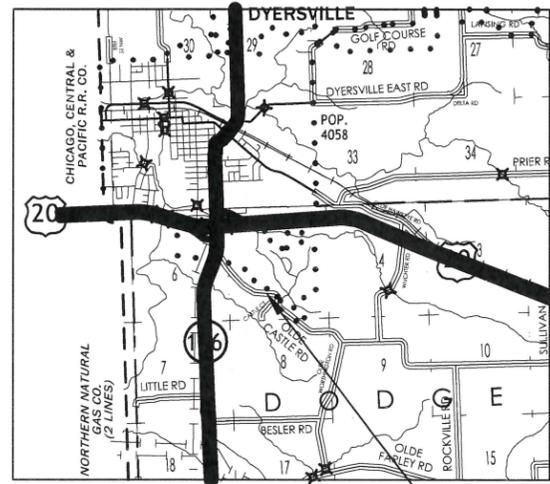

PROJECT SITE

NOTES:

PRORIETOR:
CITY OF DYERSVILLE

SITE PLAN REQUESTED BY:
CITY OF DYERSVILLE
c/o MICK MICHEL, CITY ADMINISTRATOR

PROPERTY ADDRESS:
XXXX

- NOTES:**
- CONSTRUCT ALL IMPROVEMENTS IN ACCORDANCE WITH CITY OF DYERSVILLE REQUIREMENTS, THE IOWA STATEWIDE URBAN DESIGN AND SPECIFICATIONS (SUDAS), 2025 EDITION AND ALL FEDERAL, STATE AND LOCAL REGULATIONS.
 - VERIFY LOCATIONS OF ALL EXISTING UTILITIES PRIOR TO ANY CONSTRUCTION. CALL IOWA ONE-CALL AT 1-800-292-8989
 - VERIFY LOCATIONS OF ALL PRIVATE UTILITIES PRIOR TO ANY CONSTRUCTION.
 - PLACE SILT FENCE ALONG THE LOWER SIDE OF ALL DISTURBED AREAS AND AT THE BASE OF STEEP SLOPES AS PRACTICAL.
 - EXCESS SUBGRADE / BASE MATERIAL SHALL BE REMOVED FROM THE SITE BY THE OWNER.
 - ALL CONSTRUCTION IN PUBLIC RIGHT OF WAY SHALL BE IN ACCORDANCE WITH SUDAS, SUDAS SUPPLEMENTAL SPECIFICATIONS WITH APPLICABLE PERMITS OBTAINED FOR EXCAVATION AND CONSTRUCTION.

LOCATION MAP



PROJECT SITE

<i>INDEX OF SHEETS</i>		<i>3 SHEETS</i>
<i>No.</i>	<i>Description</i>	
<i>C.01</i>	<i>TITLE SHEET</i>	
<i>C.02</i>	<i>ESTIMATE OF QUANTITIES, GENERAL NOTES</i>	
<i>C.03</i>	<i>PLAN AND PROFILE</i>	

Public Works Department

JOHN WANDSNIDER, P.E.
CITY ENGINEER
340 1st AVENUE EAST
DYERSVILLE, IOWA 52040
PHONE 563-875-7724
FAX 563-875-8238
WWW.CITYOFDYERSVILLE.COM

John F. Wandsnider P.E. #12868 Date _____

My license renewal date is December 31, 2025

Pages or sheets covered by this seal:
ALL SHEETS LISTED IN SHEET INDEX

PRELIMINARY

NOT FOR CONSTRUCTION



Client Name
CITY OF DYERSVILLE

Project Name
OLDE CASTLE ROAD SANITARY SEWER EXTENSION 2025


NUMBER:
T-62236

Location/Description
XXXXXX


Revisions	Date
Rev. Description	Date
Project Number	Issued For Bidding
Project Manager	Issued For Construction

Sheet Title
COVER

C.01

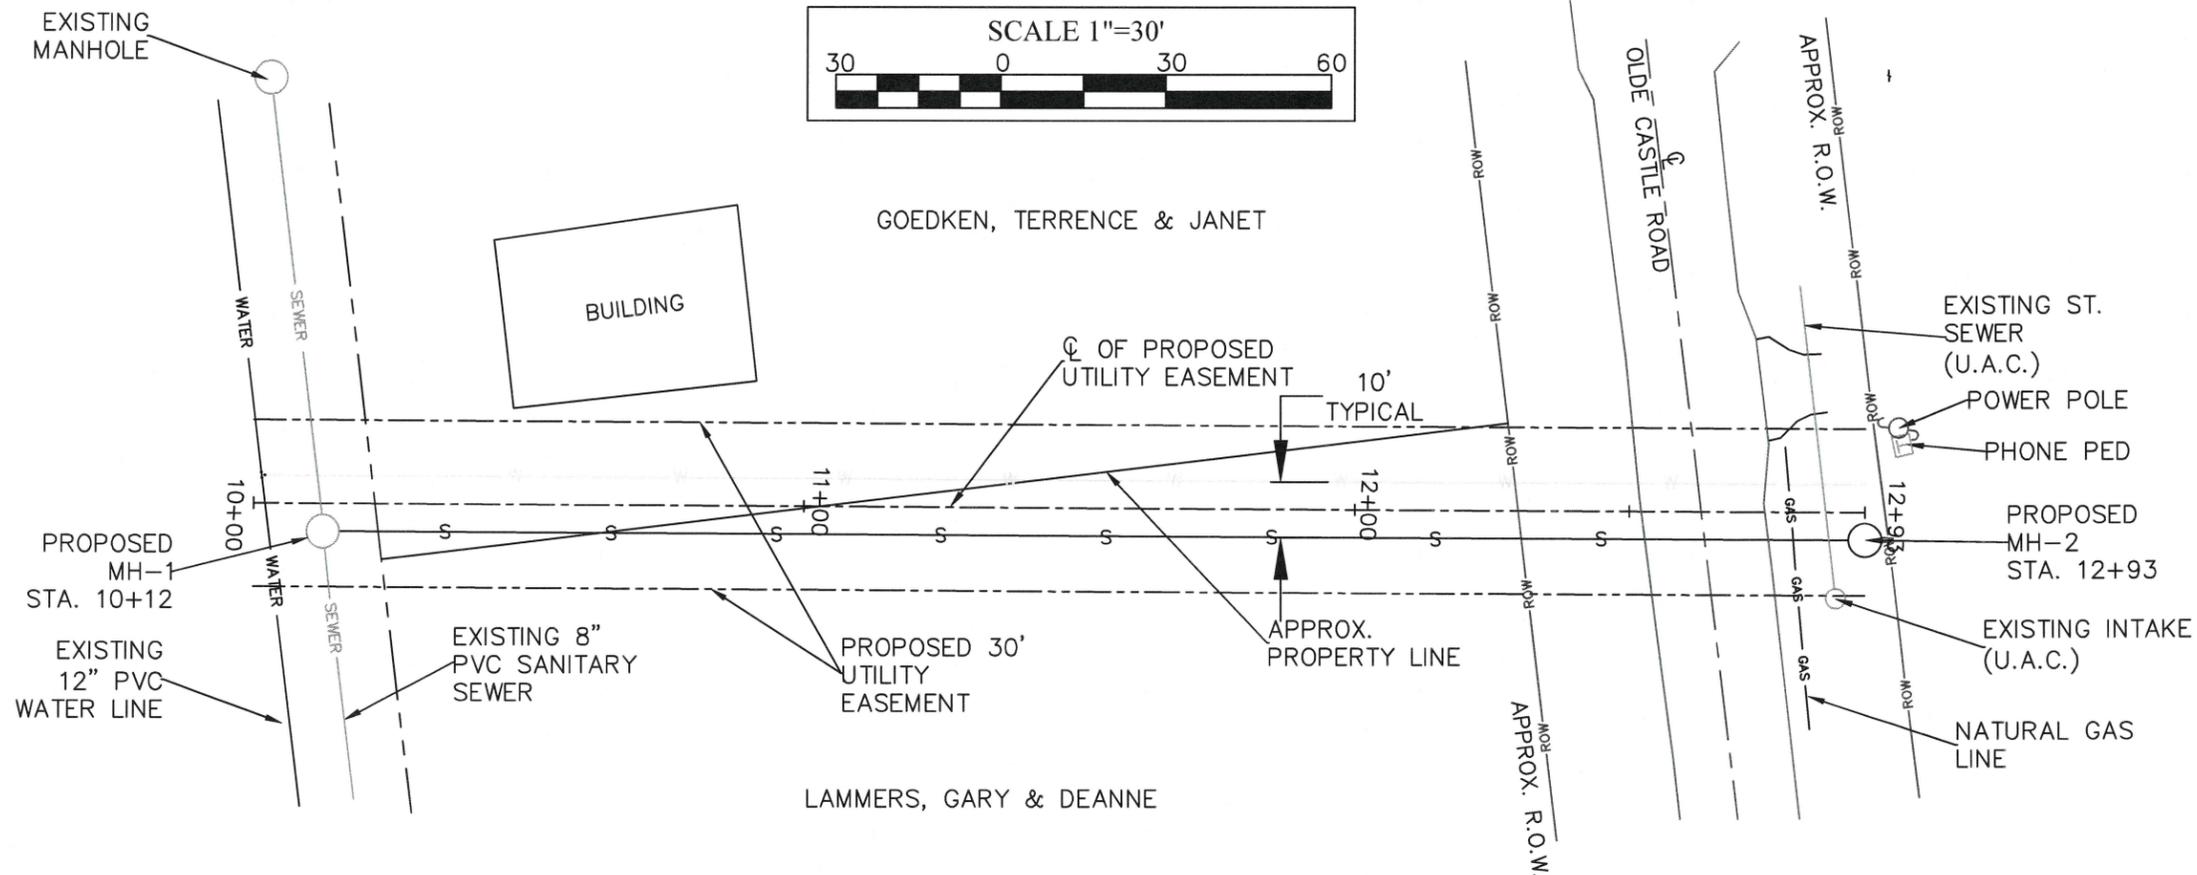

PLAN

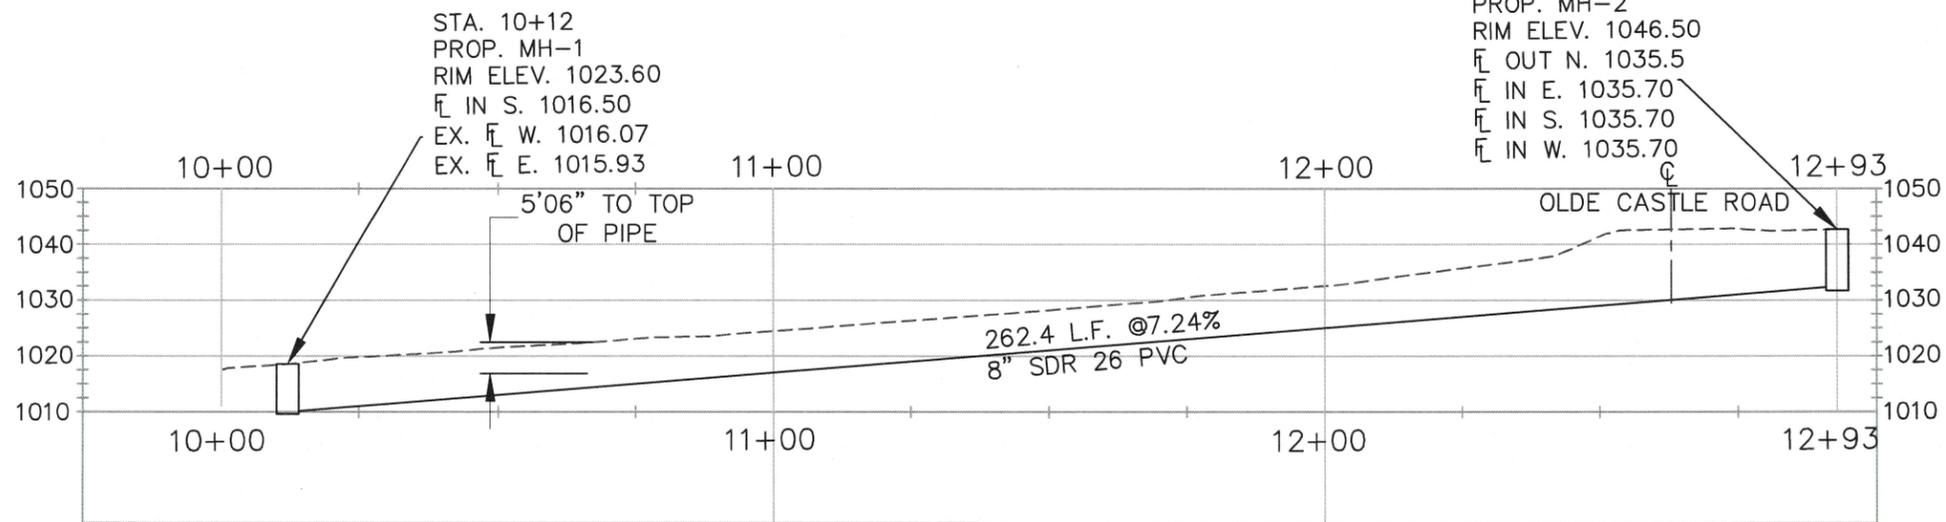

PROFILE

NOTES;
THE CONTRACTOR IS TO FIELD VERIFY THE ELEVATIONS AND SLOPES BEFORE CONSTRUCTION



Client Name

CITY OF DYERSVILLE

Project Name
OLDE CASTLE ROAD SANITARY SEWER EXTENSION 2025
NUMBER; T-62236

Location/Description

Revisions	Rev. Description	Date
	Project Number Issued For Bidding	
	Project Manager Issued For Construction	

Sheet Title

PLAN AND PROFILE

C.03

