

LAKE CITY FIRE STATION #2

383 NW HALL OF FAME DRIVE
LAKE CITY, FLORIDA 32055


PROJECT INFORMATION

BUILDING INFORMATION AND LIMITATIONS

BUILDING OCCUPANCY CLASS:	MIXED-USE: RESIDENTIAL (R-2) / STORAGE (S-1)
CONSTRUCTION TYPE:	TYPE II B
FIRE SEPARATED:	YES
SPRINKLERED:	YES
ALLOWABLE BUILDING HEIGHT:	R-2 AND S-1 = 75'-0"
ALLOWABLE BUILDING STORIES:	R-2 = 5 / S-1 = 3
ACTUAL BUILDING HEIGHT:	1 STORY, 24'-9"
ALLOWABLE BUILDING AREA (PER STORY):	R-2 = 64,000 GSF / S-1 = 70,000 GSF
ACTUAL BUILDING AREA:	7,304 GSF
AREAS AND OCCUPANT LOAD	
GROSS FLOOR AREA (R-2 INTERIOR):	4,254 GSF
GROSS FLOOR AREA (R-2 EXTERIOR):	452 GSF
GROSS FLOOR AREA (S-1):	2,598 GSF
TOTAL GROSS FLOOR AREA:	7,304 GSF
TOTAL OCCUPANT LOAD:	33 OCCUPANTS

LOCATION MAP

PROJECT LOCATION

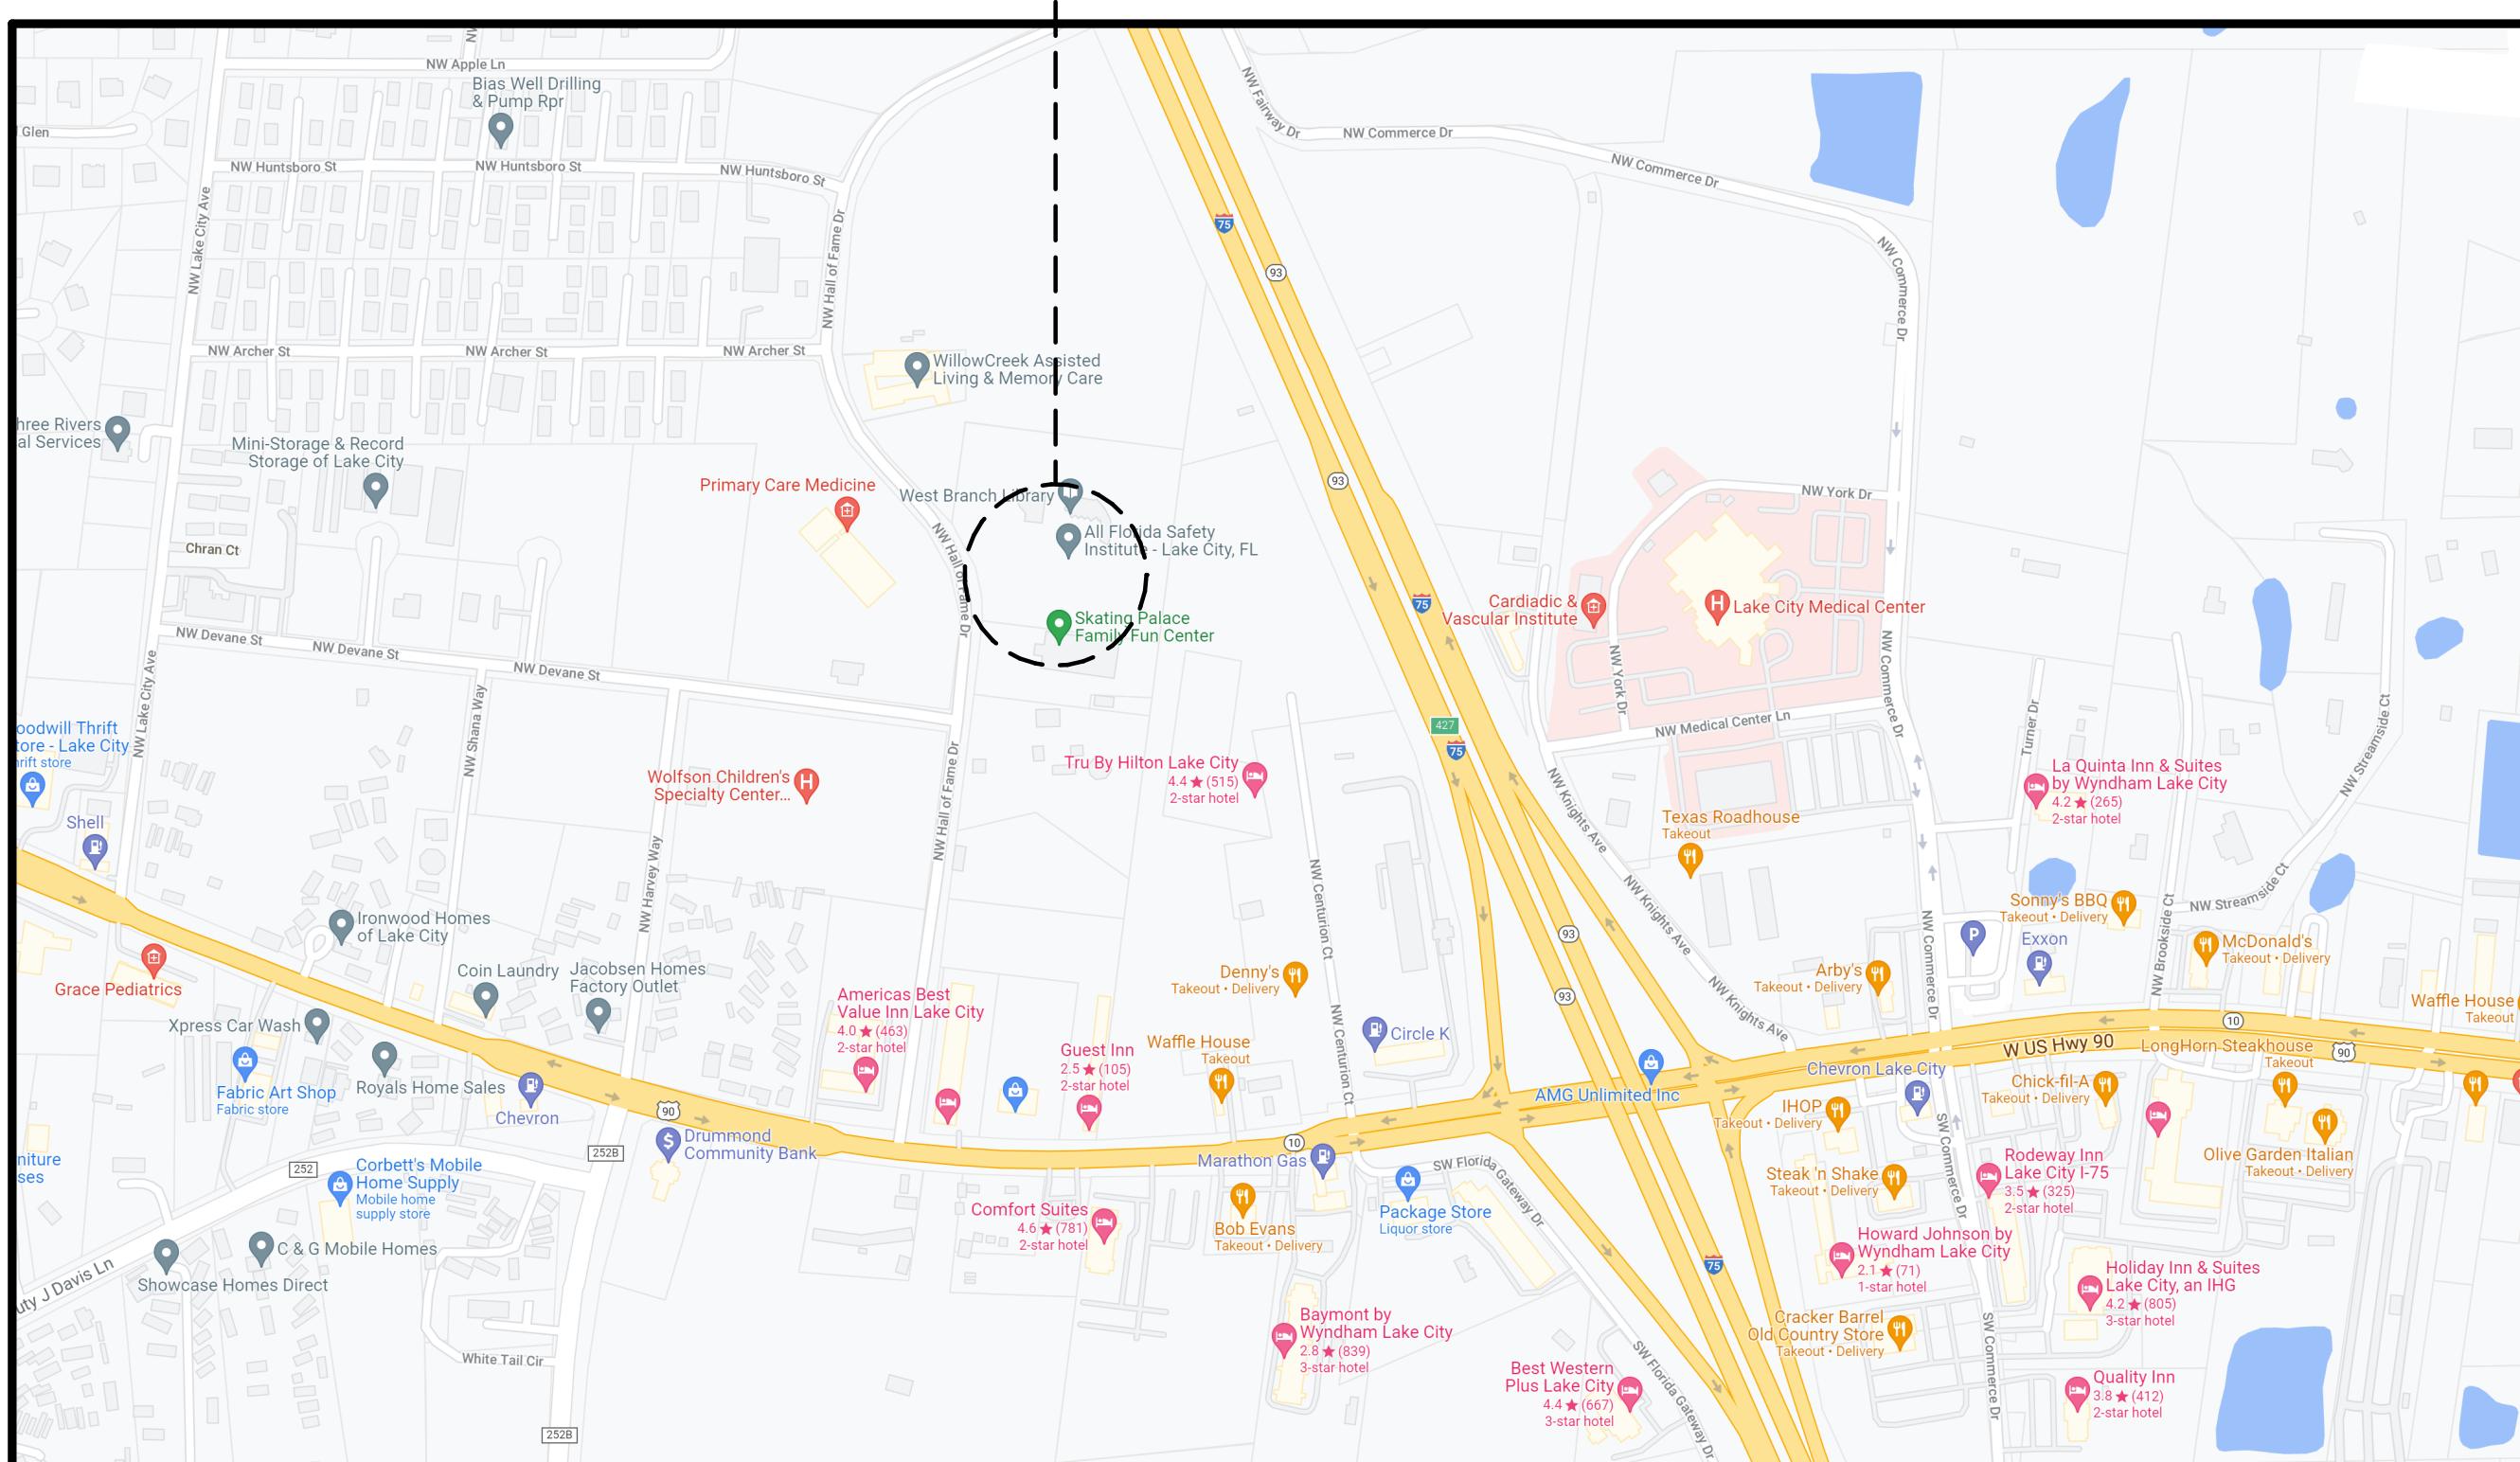

INDEX OF DRAWINGS

GENERAL

G000	COVER
G001	GENERAL NOTES, SYMBOL LEGEND AND ABBREVIATIONS
G003	TYPICAL TOILET ROOMS AND MOUNTING HEIGHTS
G004	TYPICAL MOUNTING HEIGHTS
G010	CODE COMPLIANCE
G011	CODE COMPLIANCE
G101	LEVEL 1 CODE COMPLIANCE PLAN
G201	RATED PENETRATION DETAILS - GYPSUM BOARD

MECHANICAL

M0.01	MECHANICAL LEGEND, CODES, AND NOTES
M1.10	MECHANICAL FLOOR PLAN
M1.20	MECHANICAL ROOF PLAN
M2.10	MECHANICAL DETAILS
M3.10	MECHANICAL SCHEDULES

CIVIL

C000	COVER & SHEET INDEX
C010	NOTES & LEGEND
C050	DEMOLITION & EROSION CONTROL PLAN
C100	SITE & HORIZONTAL CONTROL PLAN
C200	GRADING, DRAINAGE, & UTILITY PLAN
C250	UTILITY CONSTRUCTION DETAILS
C-1 of 1	BOUNDARY & TOPOGRAPHIC SURVEY

PLUMBING

P0.01	PLUMBING LEGEND, NOTES & DETAILS
P1.10	PLUMBING FLOOR PLAN - DOMESTIC WATER
P1.20	PLUMBING FLOOR PLAN - WASTE & VENT
P1.30	PLUMBING FLOOR PLAN - NATURAL GAS
P2.01	PLUMBING RISERS
P2.02	PLUMBING RISERS

ARCHITECTURAL

A101	LEVEL 1 FLOOR PLAN
A121	LEVEL 1 PARTITION PLAN
A131	LEVEL 1 CEILING PLAN
A140	ROOF PLAN
A161	LEVEL 1 FINISH PLAN
A181	LEVEL 1 EQUIPMENT PLAN
A200	EXTERIOR ELEVATIONS
A201	EXTERIOR ELEVATIONS
A210	BUILDING SECTIONS
A211	BUILDING SECTIONS
A220	WALL SECTIONS
A230	EXTERIOR DETAILS
A231	EXTERIOR DETAILS
A233	EXTERIOR DETAILS
A240	ROOF DETAILS
A300	ENLARGED INTERIOR VIEWS
A400	PARTITION TYPES
A410	PARTITION DETAILS
A420	INTERIOR FINISH & CASEWORK DETAILS
A440	INTERIOR FINISH DETAILS
A500	OPENING TYPES AND SCHEDULE
A510	OPENING TYPE ELEVATIONS AND DETAILS
A520	OPENING DETAILS
A521	OPENING DETAILS
A522	OPENING DETAILS

FIRE PROTECTION

F0.01	FIRE PROTECTION LEGEND, NOTES & DETAILS
F1.00	FIRE PROTECTION SITE PLAN
F1.10	FIRE PROTECTION FLOOR PLAN

ELECTRICAL

E0.01	ELECTRICAL LEGEND, CODES, AND ABBREVIATIONS
E1.00	ELECTRICAL SITE PLAN
E1.10	ELECTRICAL FLOOR PLAN - POWER
E1.20	ELECTRICAL CEILING PLAN - LIGHTING
E1.30	ELECTRICAL CEILING PLAN - FIRE ALARM
E1.40	ELECTRICAL FLOOR PLAN - MECHANICAL POWER
E1.50	ELECTRICAL FLOOR PLAN - FIRE STATION ALERTING
E2.01	ELECTRICAL RISER DIAGRAM
E3.01	ELECTRICAL SCHEDULES
E3.02	ELECTRICAL SCHEDULES
E4.01	ELECTRICAL DETAILS

STRUCTURAL

S101	STRUCTURAL NOTES
S102	STRUCTURAL DETAILS
S201	FOUNDATION PLAN & DETAILS
S301	ROOF FRAMING PLAN & DETAILS

LAKE CITY FIRE STATION #2

383 NW Hall of Fame Drive
Lake City, FL 32055

KEY PLAN

DRAWING TITLE:

COVER

PROJECT NO.: WA21031 DRAWN BY: JMO
CHECKED BY: TW

G000