

- GENERAL NOTES**
- UNLESS SHOWN OTHERWISE, ALL WIRING SHOWN IS (2) #10 AND #10 GROUND IN 1" PVC.
 - INSTALL PULL CORD IN ALL EMPTY CONDUITS.
 - PROVIDE CONCRETE BASE ROUGH-IN FIXTURES PER DETAIL (E1.0).
 - UNLESS SHOWN OTHERWISE, ALL CONDUITS BURIED 2'-6" BELOW FINISHED GRADE.
 - BRING SITE EXCAVATION AND TOPPING BACK TO ORIGINAL CONDITION IF TRENCHING IS DONE ON COMPACTED SURFACES.
 - ALL CONDUITS STUBBED OUT OF BUILDINGS SHALL BE DONE PER DETAIL (E5.0).
 - FOR EXTERIOR CAMERA INSTALLATION, SEE DETAIL.
 - FOR EXTERIOR CAMERA SCHEDULE, SEE DETAIL (E1.0) FOR TYPE AND PART NUMBER.
 - FOR POLE LIGHTING CONDUIT LAYOUT IN POLE BASE, SEE DETAIL.

PLAN NOTES

154 PROVIDE 36" CONCRETE POLE BASE PER DETAIL (E1.0)

158 TYPICAL LIGHT DISTRIBUTION OF 0.5 FOOT CANDLES, TYPICAL FOR ALL LIGHT FIXTURES OF THIS TYPE.




421 WALL MOUNT CAMERA AT ELEVATION OF 112'-0" TO CENTER.

EXTERIOR CAMERA SYMBOL

CAMERA NUMBER # AND SYMBOL	CAMERAS	PART NUMBER	QTY
(158)	AXIS P3265-LV	0237-001	1
(421)	AXIS P3738-PL-E	02635-001	14

Note: SEE SPECIFICATION SECTION 26 05 01 FOR MORE INFORMATION. PROVIDE ALL HARDWARE AS NEEDED.


3 EXTERIOR CAMERA SCHEDULE
SCALE: NTS

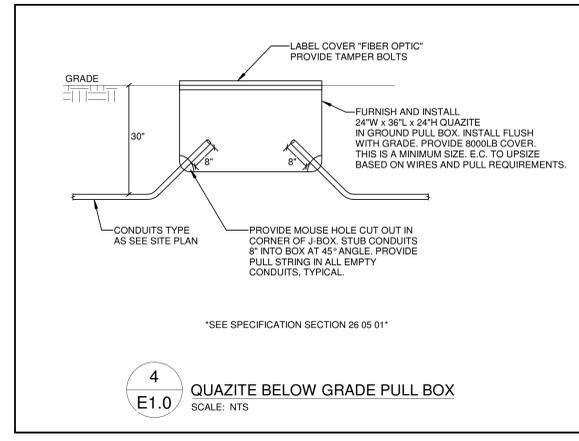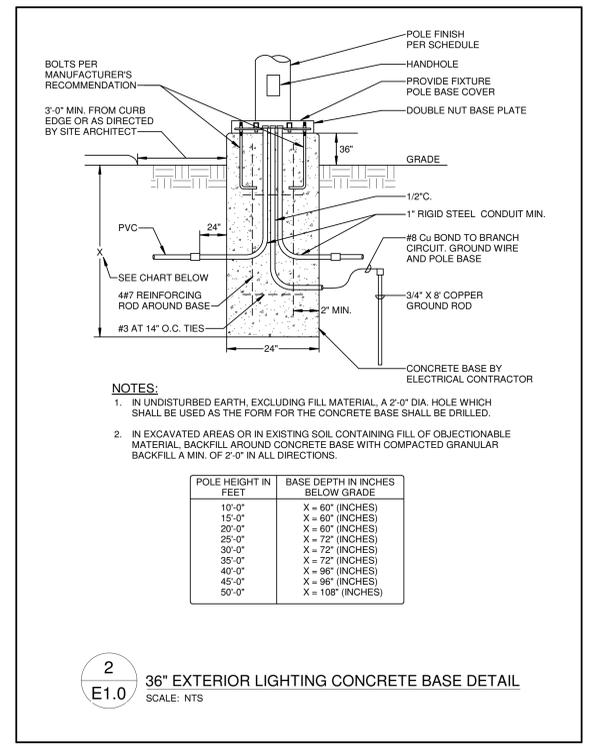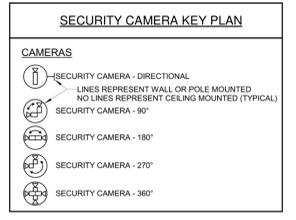

1 ELECTRICAL SITE PLAN - NEW
Scale: 1" = 30'-0"

REVISIONS:

DATE	DESCRIPTION

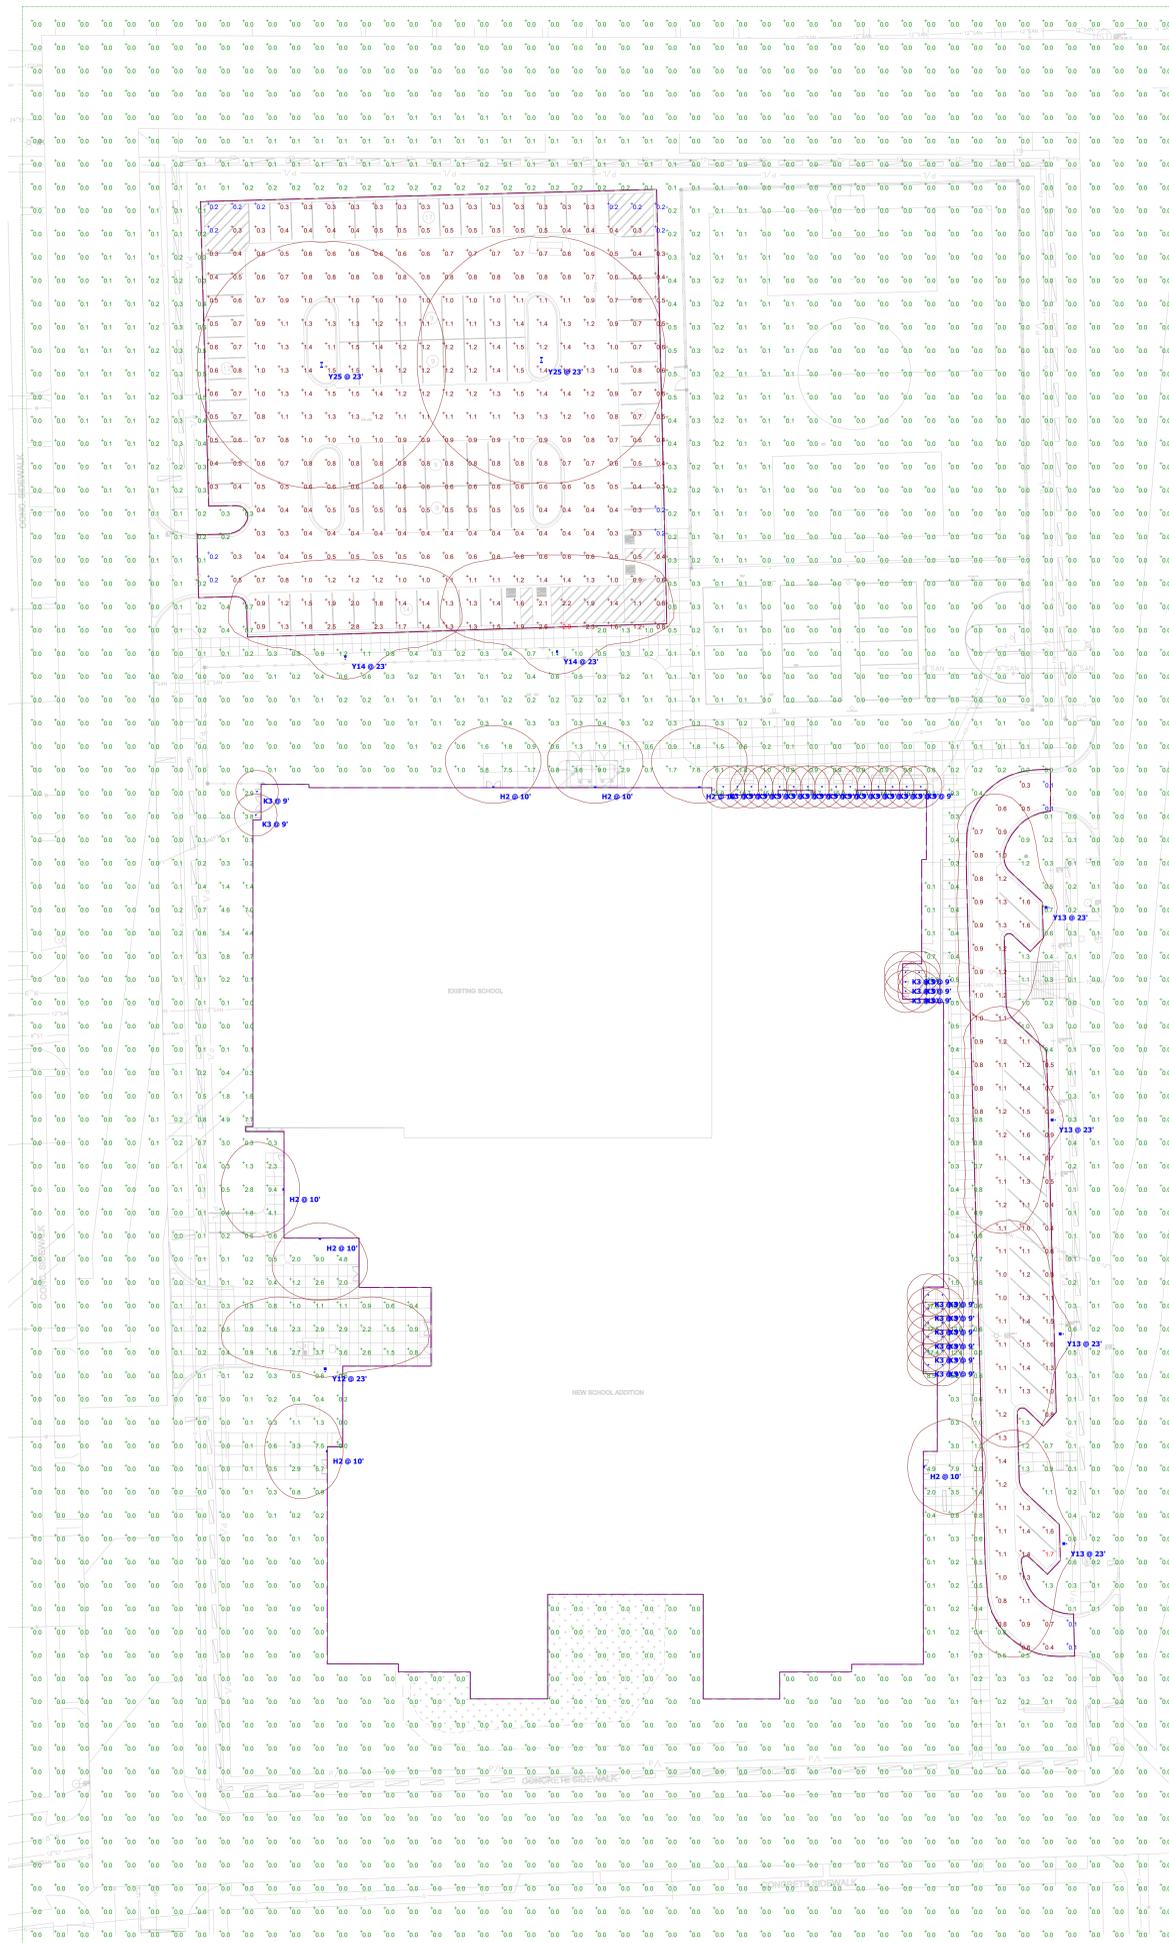

Plan View
Scale - 1" = 30'

Symbol	Label	Quantity	Image	Manufacturer	Catalog Number	Description	Number Lamps	Lumens Per Lamp	Light Loss Factor	Wattage
□	Y12	1		Lithonia Lighting	RSX1 LED P1 50K R2 HS	RSX LED Area Luminaire Size 1 P1 Lumen Package 5000K CCT Type R2 Distribution with HS shield	1	5384	0.9	51.34
□	Y13	4		Lithonia Lighting	RSX1 LED P1 50K R3 HS	RSX LED Area Luminaire Size 1 P1 Lumen Package 5000K CCT Type R3 Distribution with HS shield	1	4981	0.9	51.34
□	Y25	2		Lithonia Lighting	RSX1 LED P1 50K R5	RSX Area Fixture Size 1 P1 Lumen Package 5000K CCT Type R5 Distribution	1	7285	0.9	102.68
□	H2	7		Lithonia Lighting	ARC2 LED P3 50K	ARC2 LED WITH P3 - PERFORMANCE PACKAGE, 5000K	1	3410	0.9	23.7345
□	Y14	2		Lithonia Lighting	RSX1 LED P2 50K R4 HS	RSX LED Area Luminaire Size 1 P2 Lumen Package 5000K CCT Type R4 Distribution with HS shield	1	6554	0.9	72.95
○	K3	35		Lithonia Lighting	LIBR6 ALD1 (750LM) SWW1 (5000K) AR LSS MWD 80CRI	6IN LIBR Retrofit 750LM 5000K Clear Semi-Specular Medium Wide 80CRI	1	957	0.9	9.06

Statistics

Description	Symbol	Avg	Max	Min	Max/Min	Avg/Min
EAST PARKING LOT	+	1.0 fc	1.7 fc	0.1 fc	17.0:1	10.0:1
NORTH PARKING LOT	+	0.8 fc	2.9 fc	0.2 fc	14.5:1	4.0:1
SITE	+	0.3 fc	17.5 fc	0.0 fc	N/A	N/A