
MSI GENERAL CORPORATION P.O. BOX. 7 OCONOMOWOC, WI 53066

ISSUE DATES:				
Budget:	02/12/2024			
Site Plan Submittal:	04/08/2024			
Plan Comm. Submittal:	08/08/2024			
Contract:	xx/xx/xxxx			
State Submittal / Permit:	xx/xx/xxxx			
Record Drawings:	xx/xx/xxxx			
REVISIONS:				
1				
'				


GENERAL PHONE: 262-367-3661 WWW.MSIGENERAL.COM SINGLE SOURCE RESPONSIBILITY TM

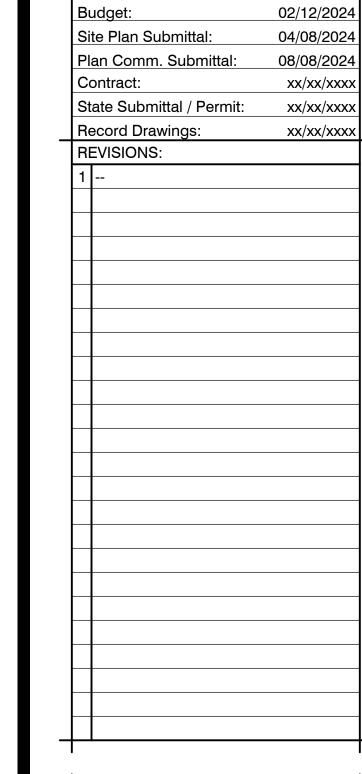

PROJECT ADDRESS: PROJECT NAME Consoildated Ind. Building Addition STREET ADDRESS 1207 Boomer Street CITY/ STATE / ZIP Watertown WI 53094 ALL WORK TO BE COMPLETED AS SHOWN, AND IN ACCORDANCE WITH THE LATEST EDITION OF THE

1		
Architect:	Engineer:	Reviewed By:
BJZ	Pinnacle	
Sheet Title: LIGHTI SITE P Sheet Num	NG LAN	
	104	
Project Nur	nber:	
P1	360	1

ARCHITECTURAL SITE PLAN 1" = 30'-0"

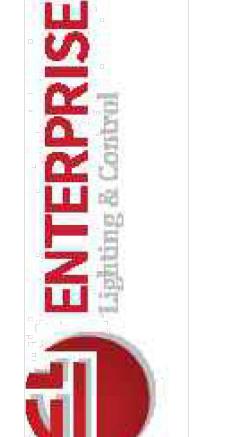

NOTES:

- Customers are responsible for confirming mounting heights, fixture suspension types/lengths, color temperature, CRI, linear fixture lengths, pole lengths, and bollard heights/ lengths prior to ordering.
- Mounting height (MH) is measured from the bottom of the fixture to the floor.
- This Lighting layout assumes the following unless values are specified and must be confirmed by the customer prior to ordering.
- •• Color Temperature is 4000K
- Room reflectance of 80, 50, 20 for standard ceilings and 50, 50, 20 for exposed ceilings
- Wall sconces are mounted at 7 feet for calculations.

