

## Luminaire Schedule

Symbol	Qty	Tag	Arrangement	Label	Description	Luminaire Lumens	Luminaire Watts	Total Watts	LLF	Mounting Height
	3	S1	Single	ALW LS210 T5 G2 FSK-6500Lm-40K	ALW LS210 T5 G1 FSK-6500Lm-40K	6827	40.94	122.82	0.950	25
	6	S2	Single	BONGO-60-4K-UNV	Solera BONGO Post Top Fixture, 60W, 8010lm, 4000K, 120-277v,	5697	59.4	356.4	0.950	10
	6	WP	Single	WFV LS70 G2 FSK-3000Lm-40K	WFV LS70 G2 FSK-3000Lm-40K	2996	18	108	0.950	10

## Calculation Summary

Label	CalcType	Units	Avg	Max	Min	Avg/Min	Max/Min
Lot Line	Illuminance	Fc	0.35	4.5	0.0	N.A.	N.A.
Site Calcs	Illuminance	Fc	0.43	11.8	0.0	N.A.	N.A.
Parking Lot	Illuminance	Fc	0.76	2.0	0.2	3.80	10.00
Walkway	Illuminance	Fc	2.52	10.3	0.1	25.20	103.00

Vertical Lighting + Controls  
558 Plate Dr. Ste. 1  
East Dundee IL 60118

VERTICAL  
LIGHTING + CONTROLS


Watertown Apartments  
Waterville, WI

REVISIONS  
# Description Date

FILE NAME: Watertown Apartments  
MADE BY: ALEC CHECKED: ALEC  
DATE: 1/12/2026

LIGHTING PHOTOMETRIC ANALYSIS

PAGE NO. 1 BID PKG.  
DRAWING NO. 1

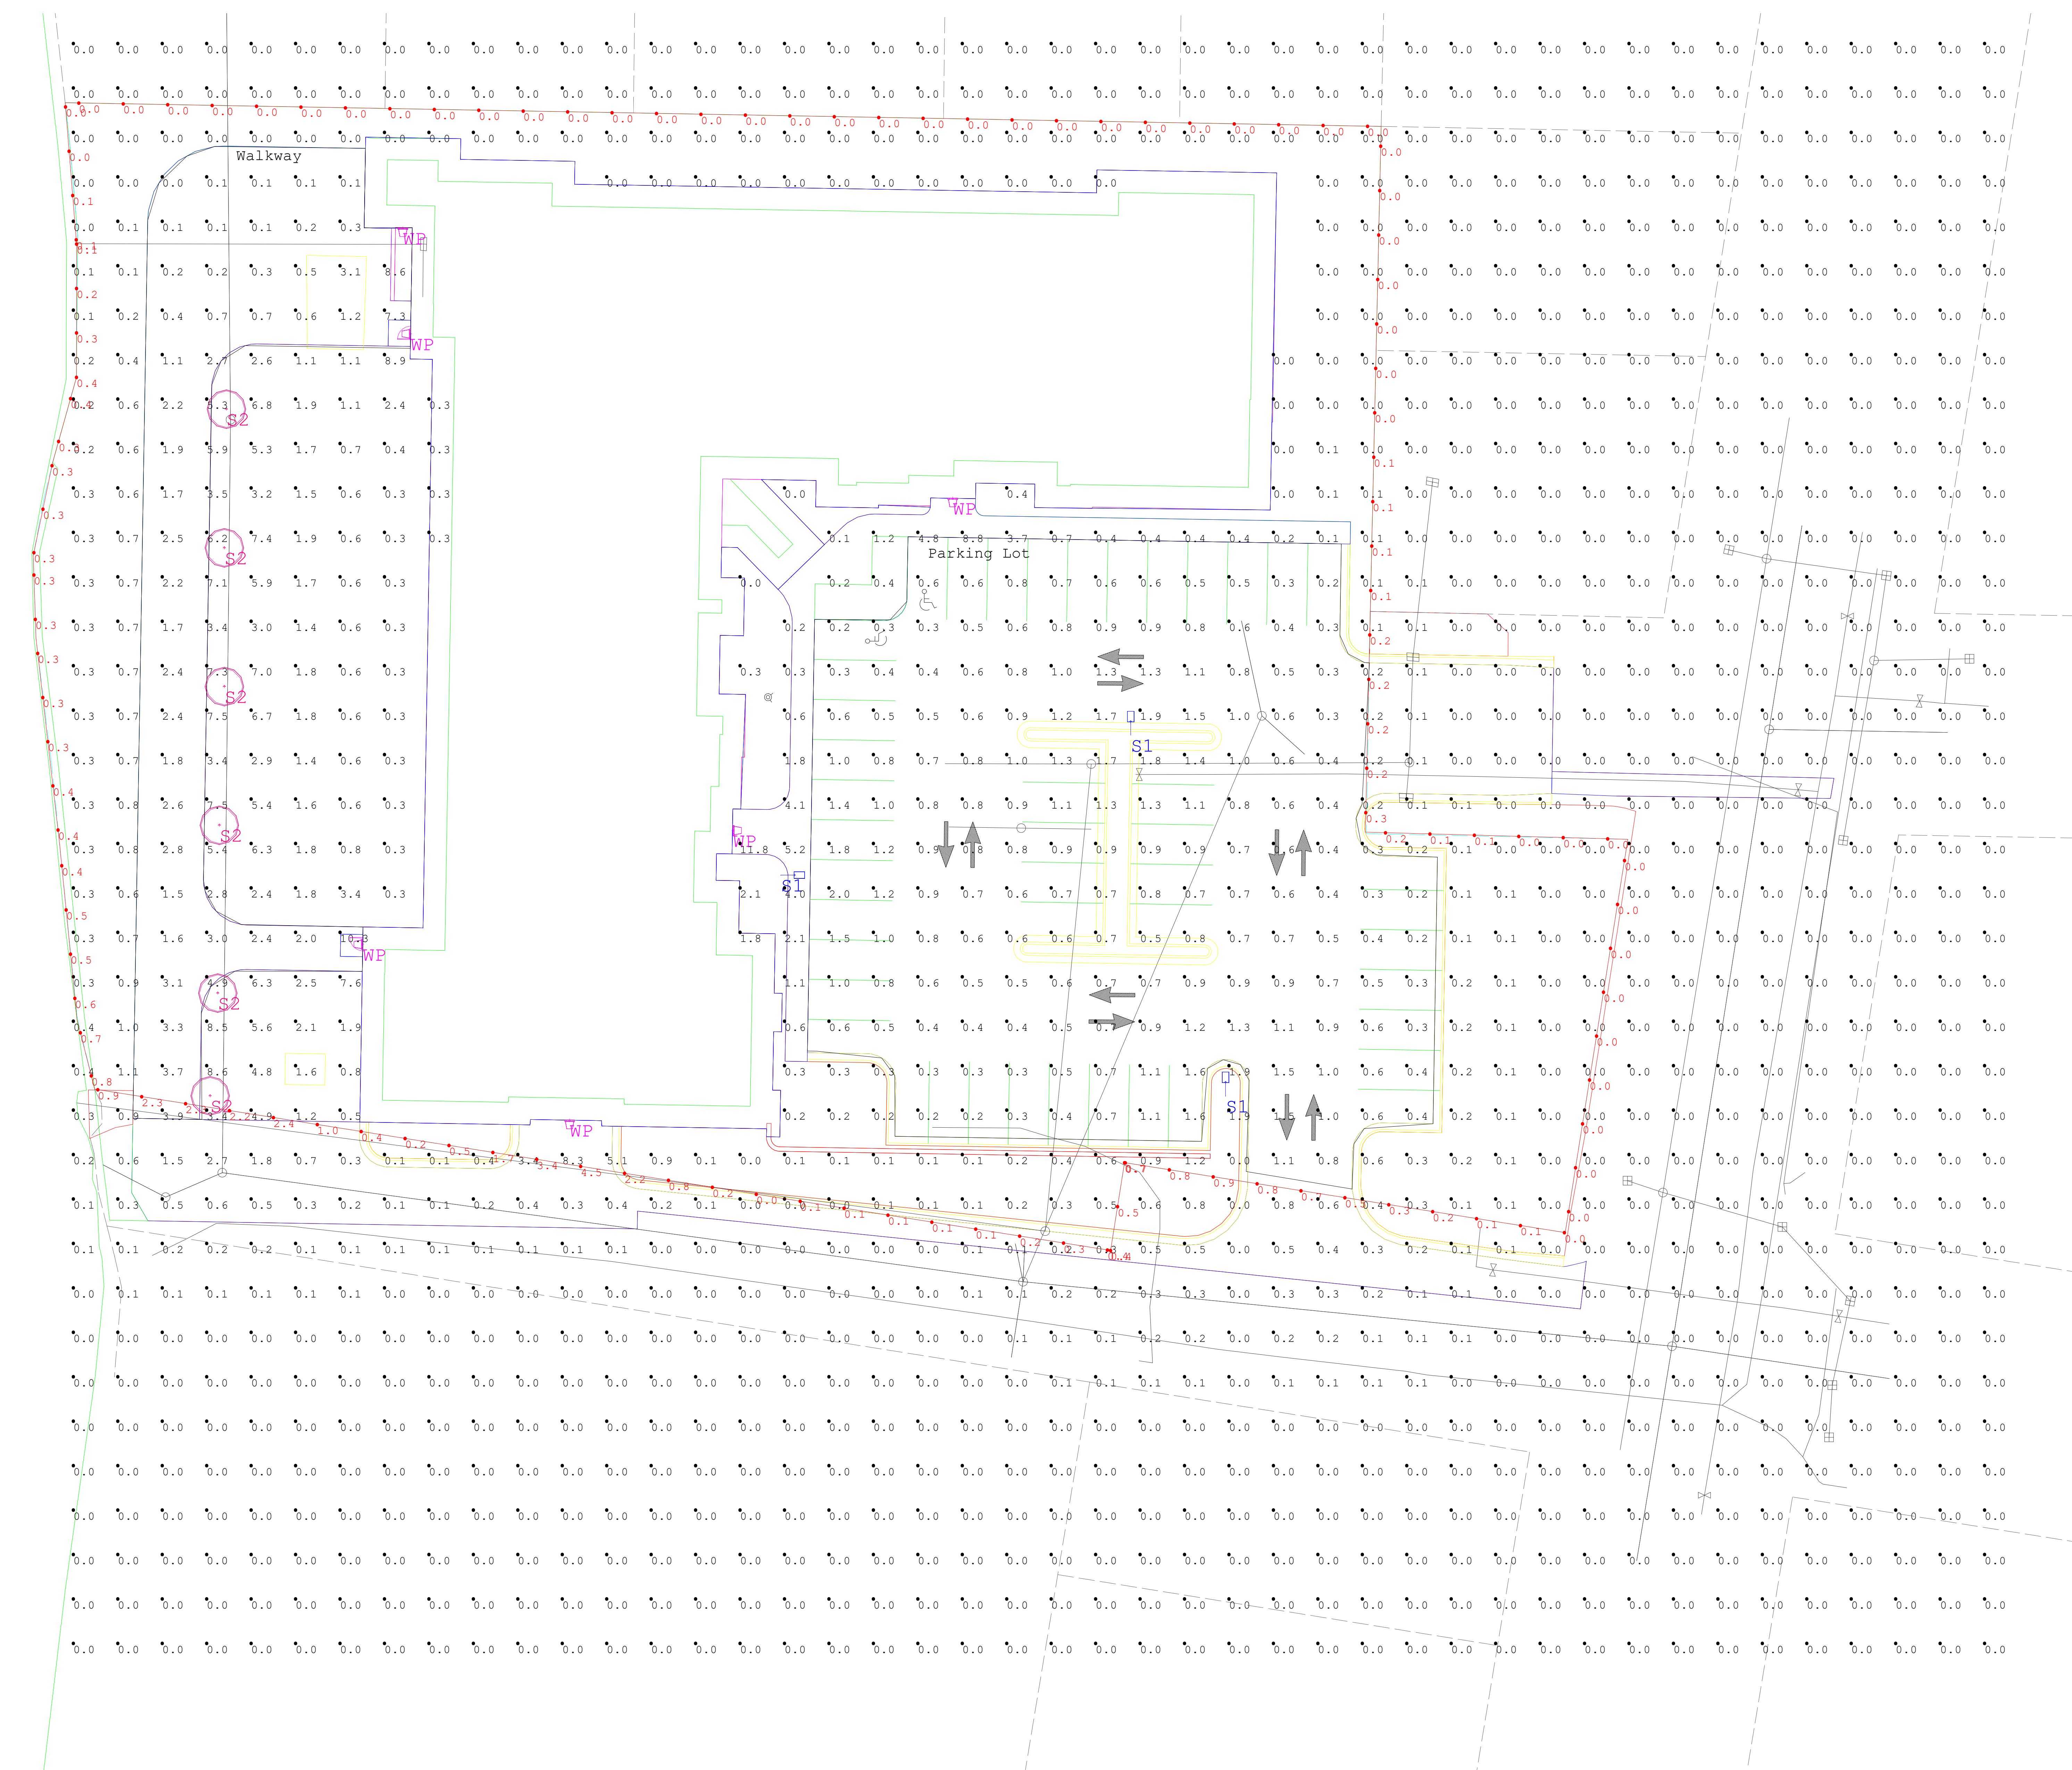

Vertical Lighting + Controls  
558 Plate Dr. Ste. 1  
East Dundee IL 60118

VERTICAL  
LIGHTING + CONTROLS


Watertown Apartments

Waterville, WI

FILE NAME: Watertown Apartments  
MADE BY: ALEC  
CHECKED: ALEC  
DATE: 1/12/2026

LIGHTING PHOTOMETRIC  
ANALYSIS

PAGE NO. 2  
BID PKG. 2  
DRAWING NO. 2  
CROSS SECTION 2

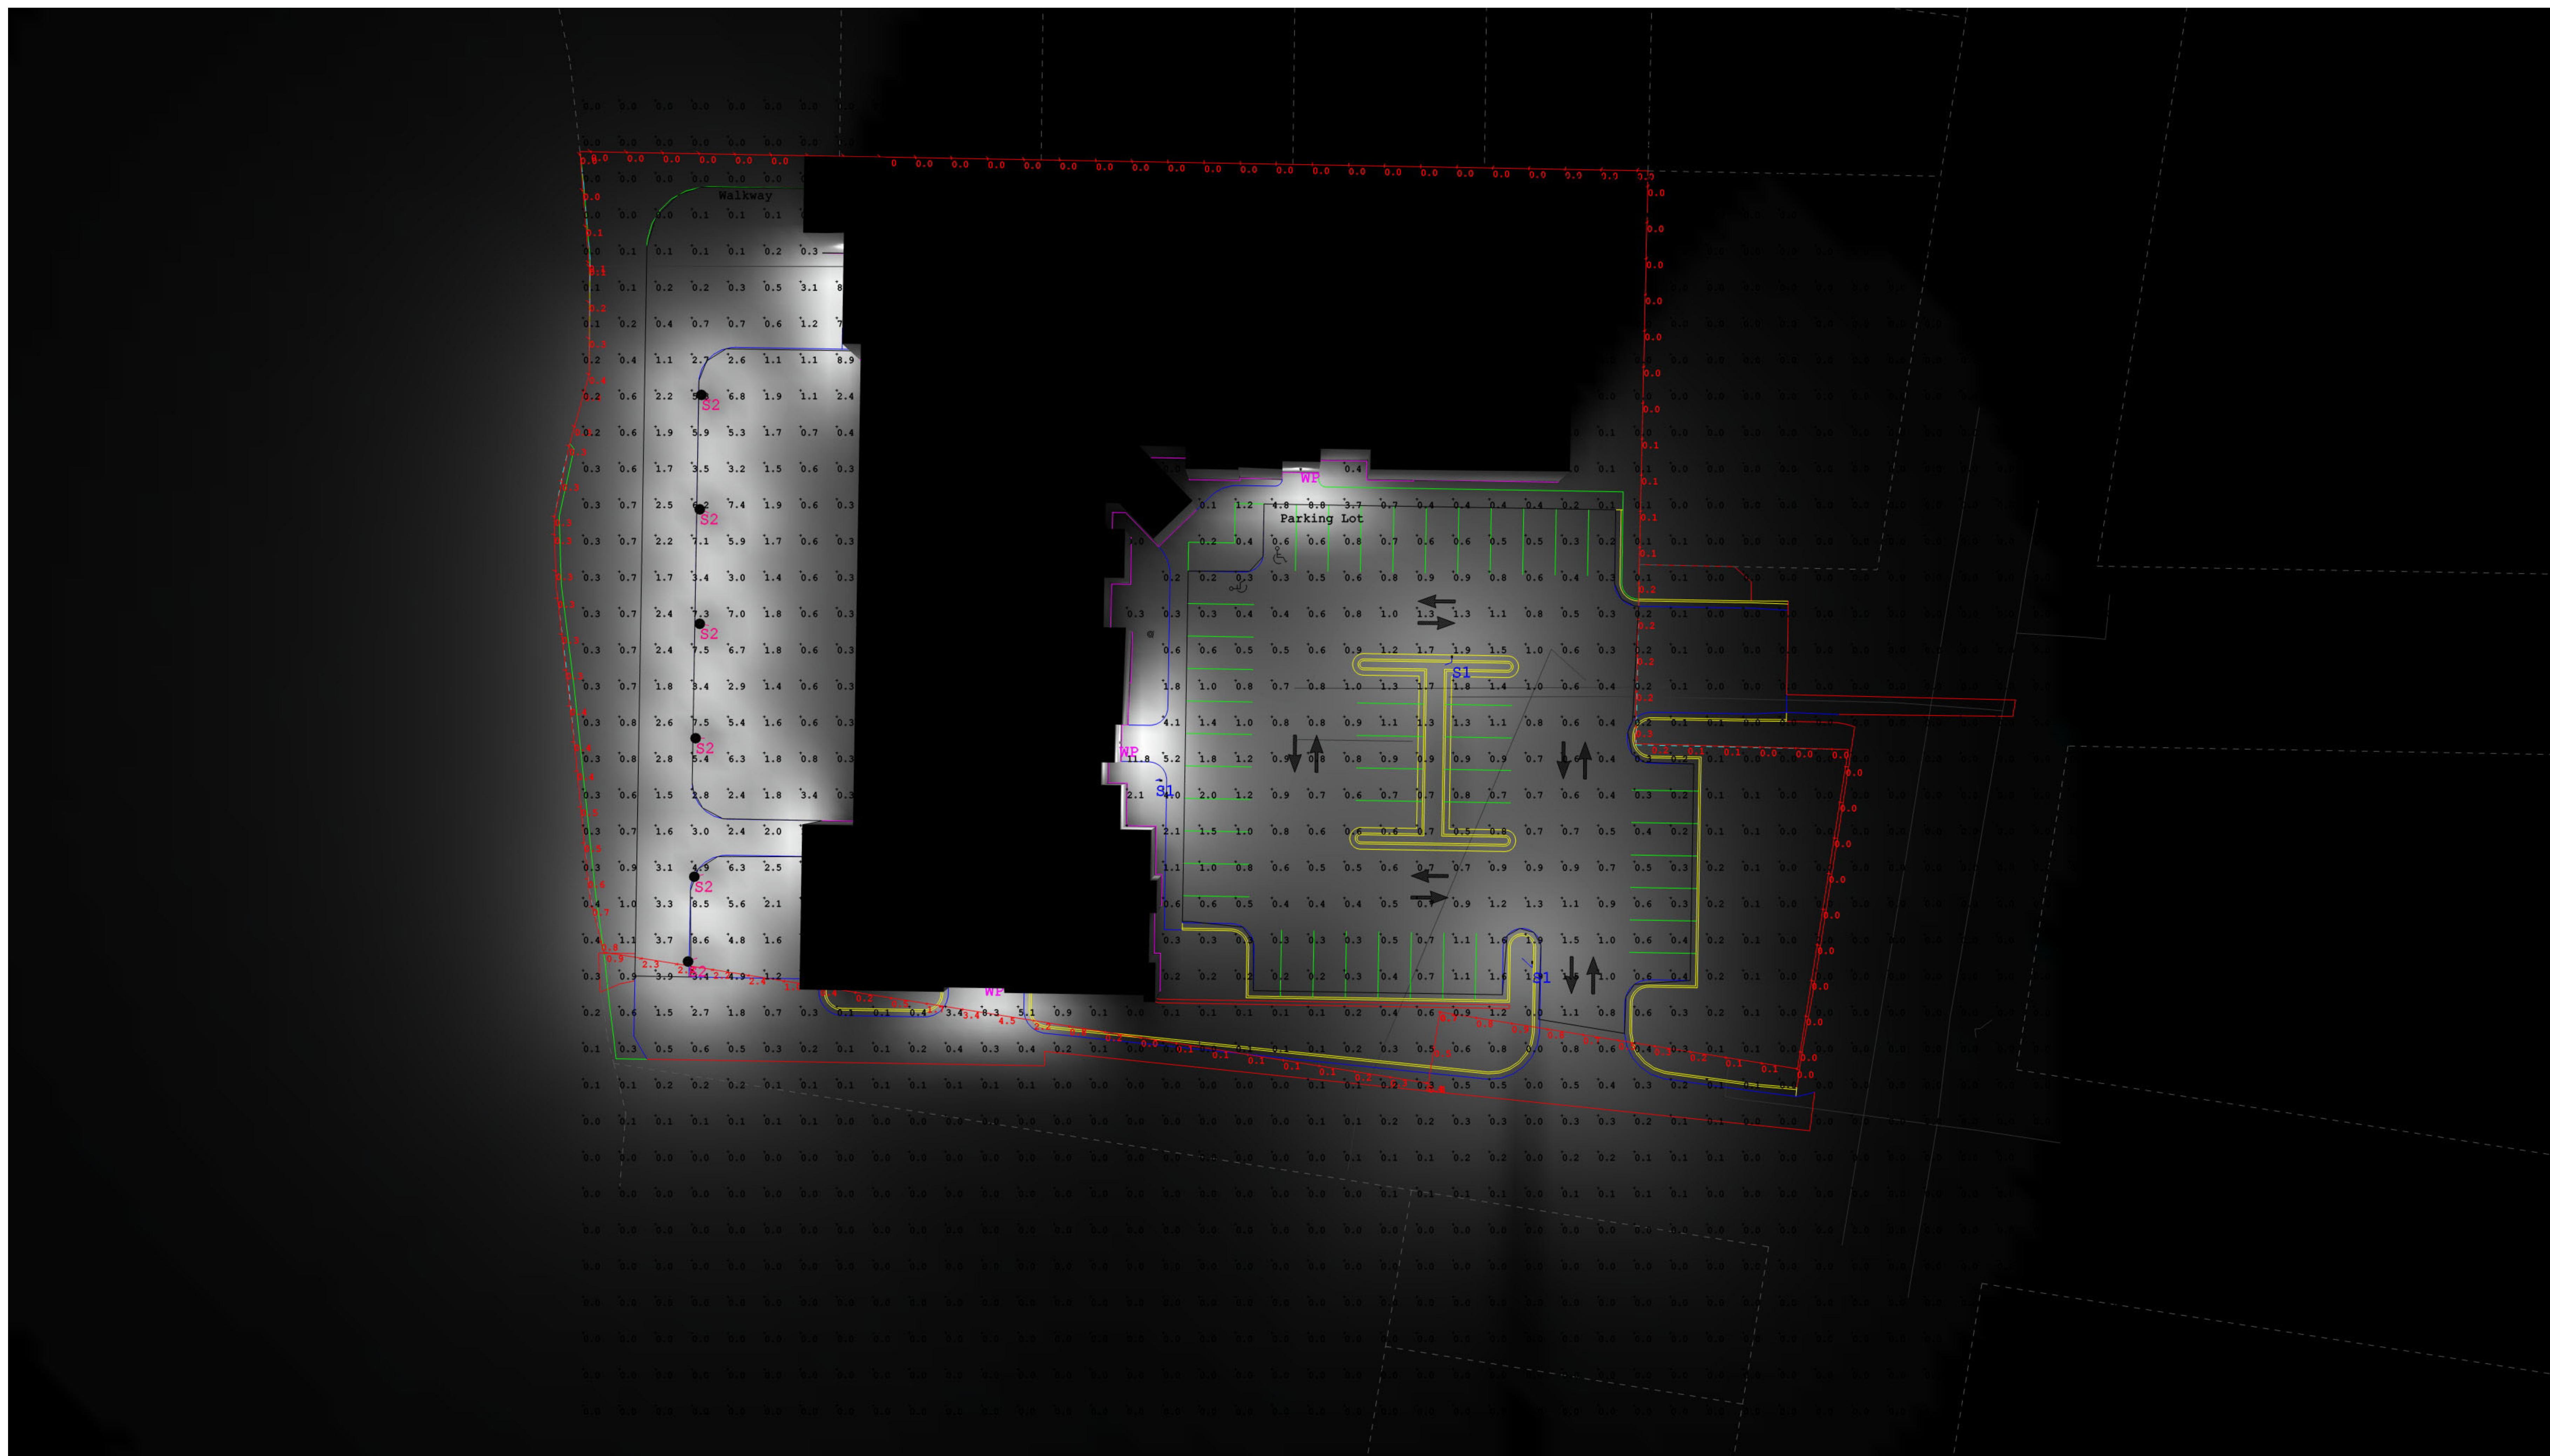

FILE NAME: Watertown Apartments  
 MADE BY: ALEC CHECKED: ALEC  
 DATE: 1/12/2026

LIGHTING PHOTOMETRIC ANALYSIS

DISCLAIMER: BASED ON THE INFORMATION PROVIDED, ALL DIMENSIONS AND LUMINAIRES LOCATIONS SHOWN REPRESENT RECOMMENDED POSITIONS. THE PROJECT ENGINEER AND/OR ARCHITECT MUST DETERMINE APPLICABILITY OF THE LAYOUT TO EXISTING OR FUTURE FIELD CONDITIONS. THE PHOTOMETRIC DATA FOR THIS ILLUMINATING SYSTEM IS FROM A COMPUTER MODEL. IT IS THE RESPONSIBILITY OF THE PROJECT ENGINEER AND/OR ARCHITECT TO DETERMINE IF THE ILLUMINATING SYSTEM IS APPROPRIATE FOR THE PROJECT. THIS DRAWING IS FOR ESTIMATING PURPOSES ONLY. FINAL CONSTRUCTION DRAWINGS, LIGHTING LAYOUTS AND CALCULATIONS ARE THE RESPONSIBILITY OF A LICENSED ARCHITECT OR ENGINEER. IN NO EVENT SHALL VERTICAL LIGHTING + CONTROLS BE LIABLE FOR ANY DIRECT, INDIRECT, INCIDENTAL, SPECIAL, OR CONSEQUENTIAL DAMAGES ARISING OUT OF THE USE OF THIS DRAWING. VERTICAL LIGHTING + CONTROLS HAS BEEN ADVISED OF THE POSSIBILITY OF SUCH DAMAGES. VERTICAL LIGHTING + CONTROLS MAKES NO REPRESENTATIONS OR WARRANTIES WITH RESPECT TO THE ACCURACY OR COMPLETENESS OF THE CONTENTS OF THIS DOCUMENT. IN ALL INSTANCES, IT IS RECOMMENDED HAVE A PILOT INSTALLATION IN PLACE TO VERIFY LIGHT LEVELS AND APPEARANCE AND WHAT IS EXPECTED PRIOR TO COMPLETING A TOTAL INSTALLATION AND LAYOUT OF THE PRODUCT(S).

PAGE NO. 3 BID PKG. 3

Watertown Apartments

Waterville, WI

Vertical Lighting + Controls  
 558 Plate Dr. Ste. 1  
 East Dundee IL 60118

VERTICAL  
 LIGHTING + CONTROLS