


**Schedule**

Symbol	Label	QTY	Manufacturer	Catalog	Description	Number Lamps	Lamp Output	LLF	Input Power
^ ○	A	56	Lithonia Lighting	LDN6 27/05 LO6AR LD	6IN LDN, 2700K, 500LM, CLEAR, MATTE DIFFUSE REFLECTOR, CRI80	1	449	0.87	5.83
^ □	B	2	Lithonia Lighting	DSX2 LED P1 27K 80CRI AFR	D-Series Size 2 Area Luminaire P1 Performance Package 2700K CCT 80 CRI Automotive Front Row	1	17640	0.87	134.5

**Statistics**

Description	Symbol	Avg	Max	Min	Max/Min	Avg/Min
Calc Zone #2	+	0.6 fc	6.1 fc	0.1 fc	61.0:1	6.0:1

**GREENWAY COURT  
CONTRACTOR SHOP BUILDINGS  
Lot T3 Greenway Court  
Whitewater, WI 53190**

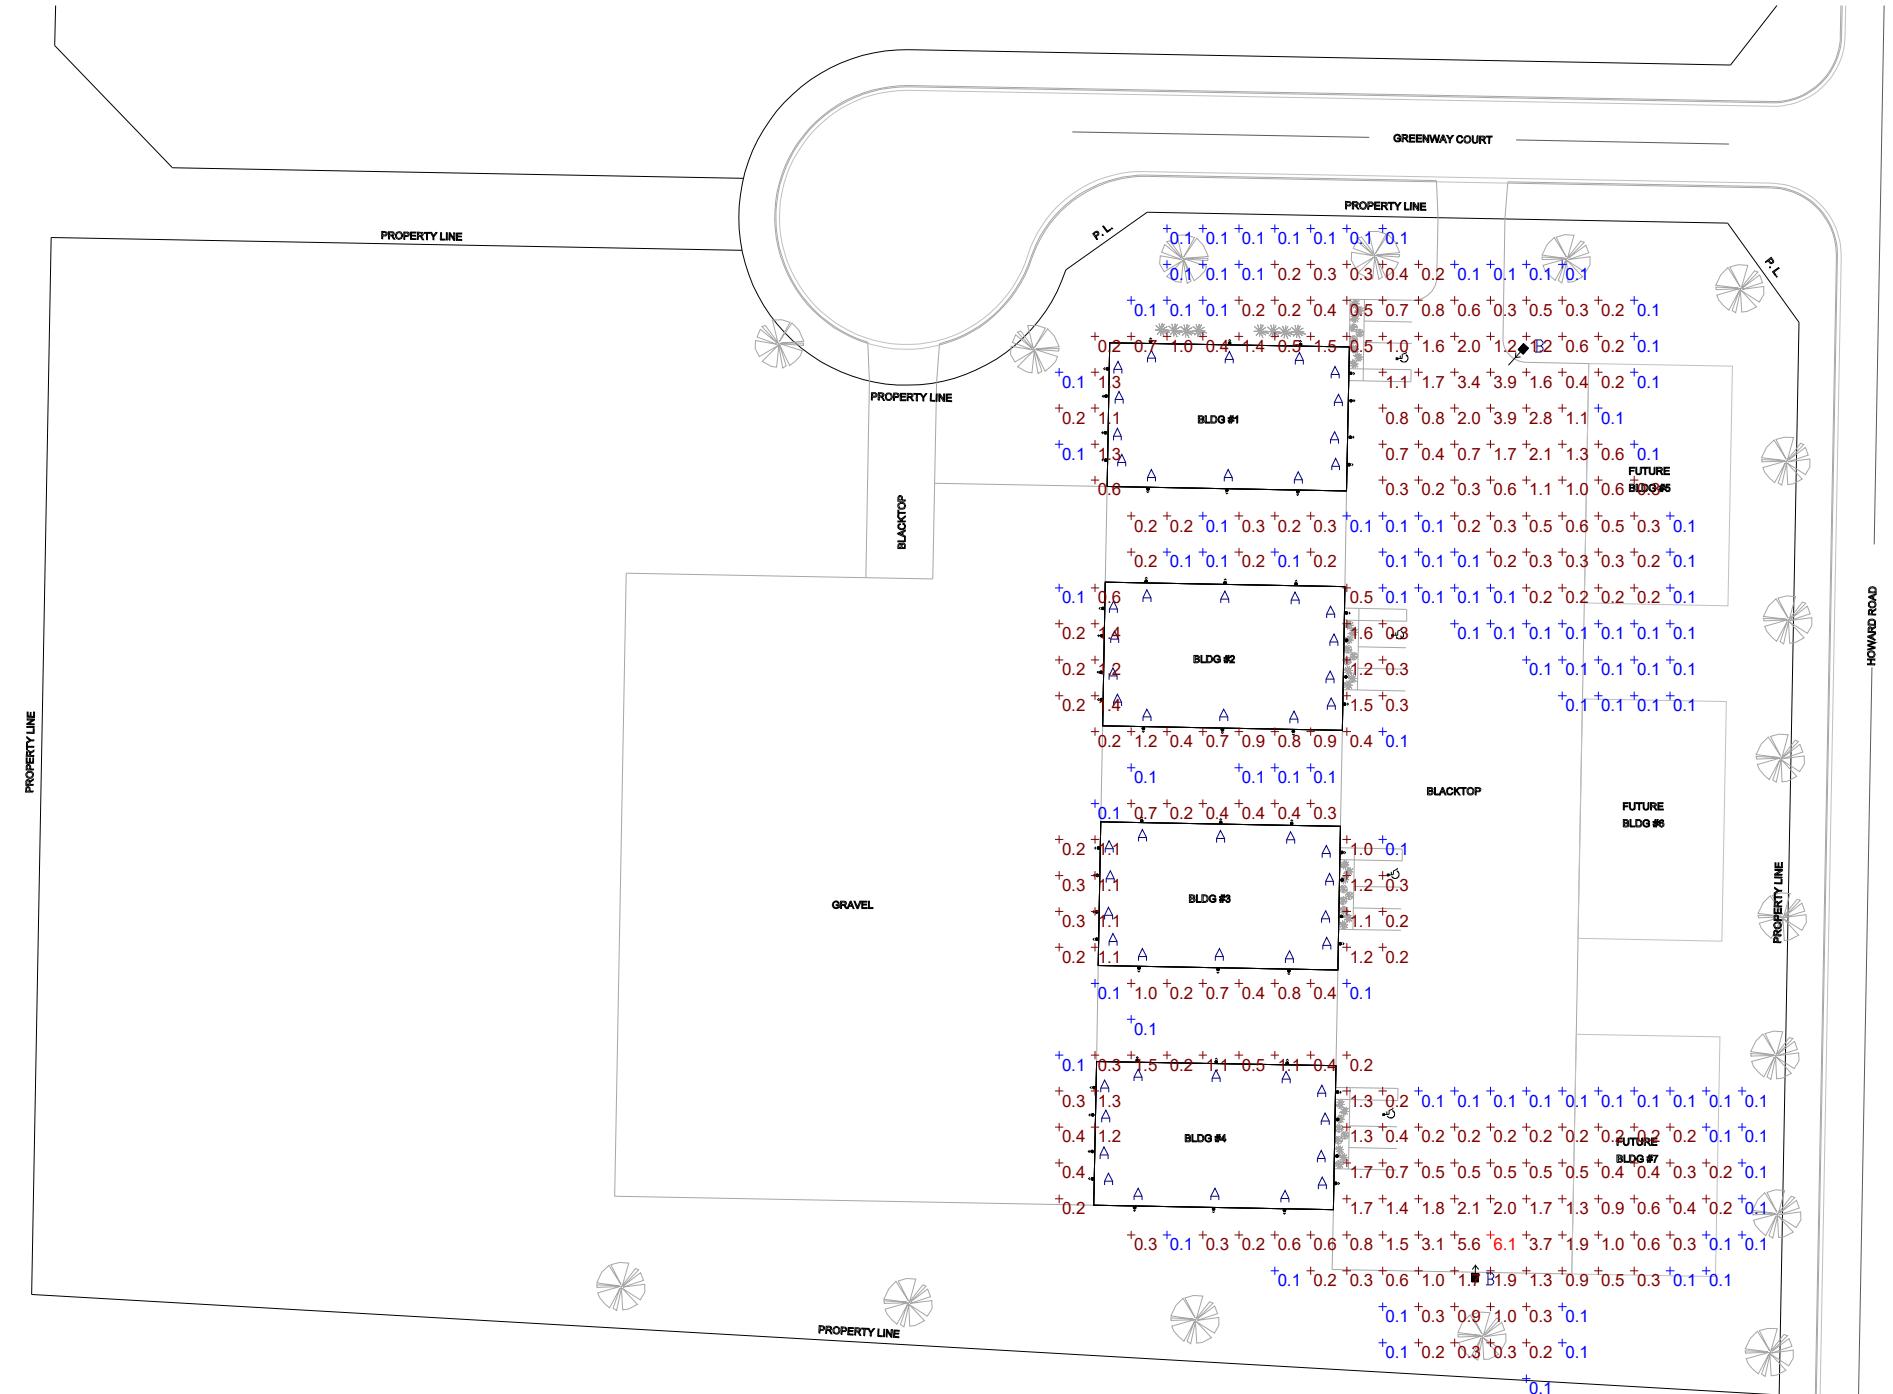

SITE LIGHTING PLAN  
Scale: N.T.S.  
Date: December 31, 2024

**Designer**  
CL  
**Date**  
12/31/2024  
**Scale**  
Not to Scale  
**Revision No.**

**Summary**

**SP-2**